



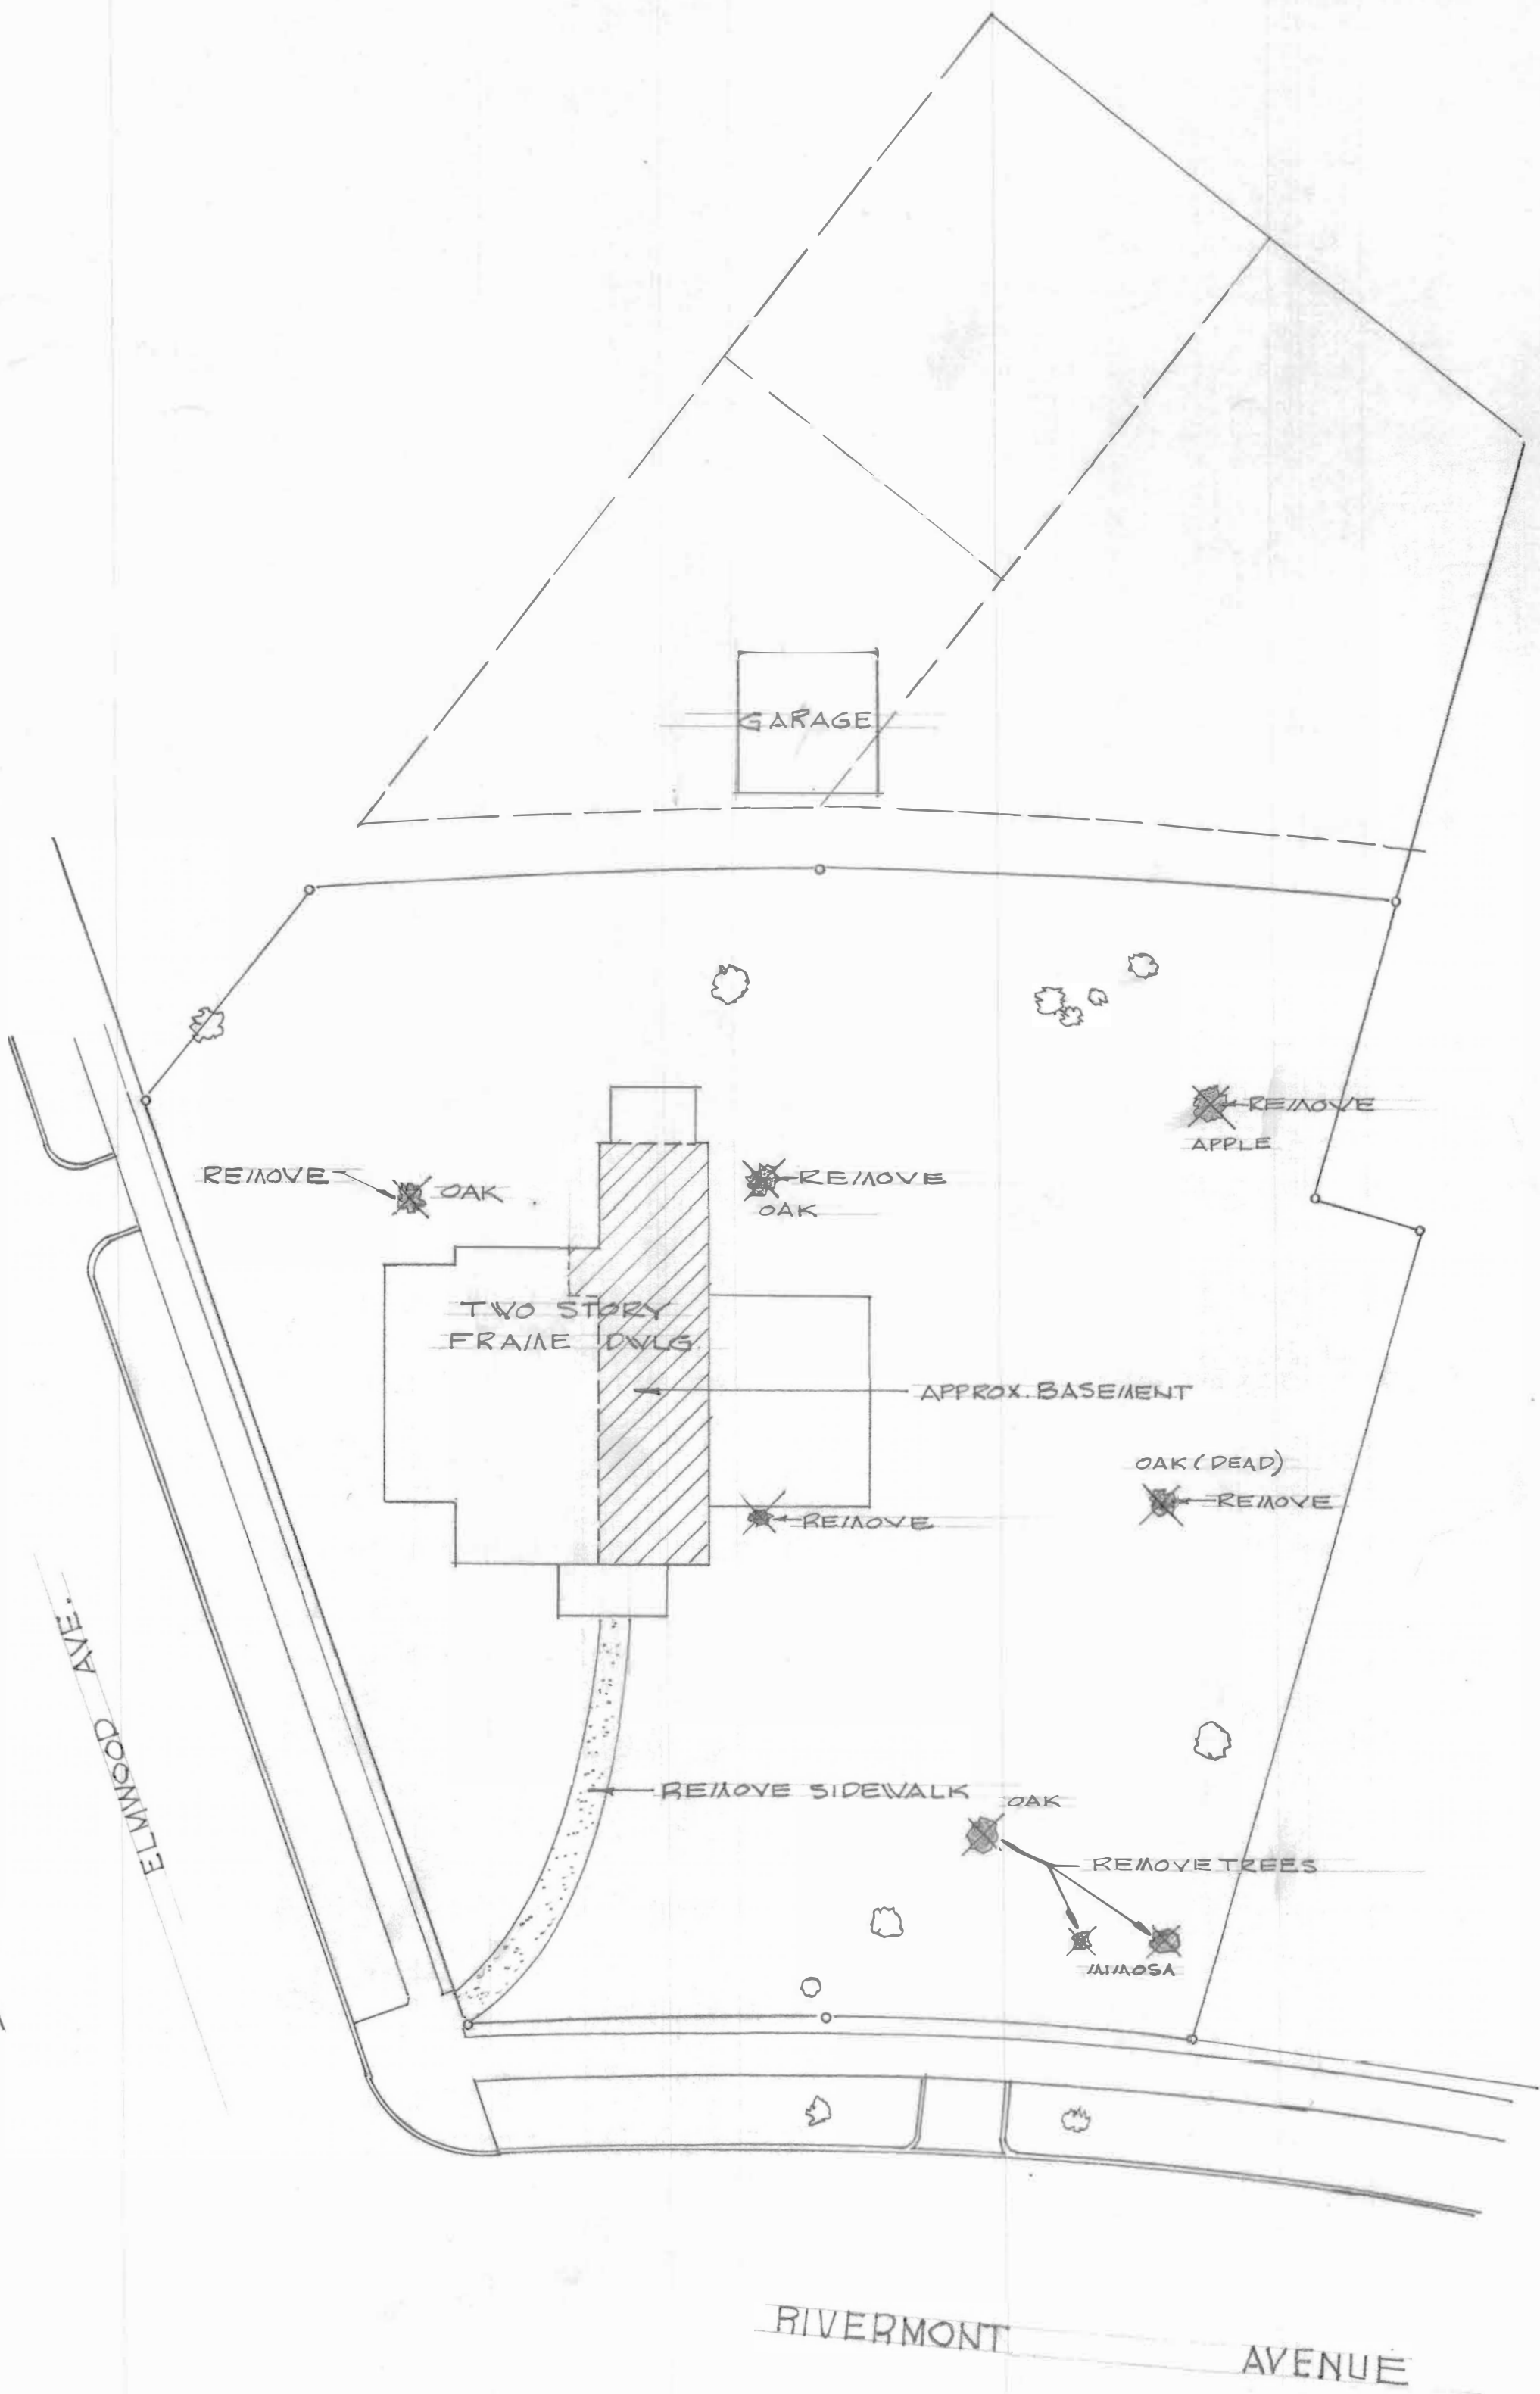

CRESS - RHODES & ASSOCIATES ARCHITECTS 714 COURT STREET, LYNCHBURG, VIRGINIA		SHEET NO. D-1	OF 1
FIRST FEDERAL SAVINGS & LOAN RIVERMONT BRANCH LYNCHBURG, VIRGINIA		COMM. NO. DATE DRAWN CHECKED 7110 2 DEC 71 CH.W. W.C.B.	
COMMONWEALTH OF VIRGINIA WILLARD C. RHODES CERTIFICATE NO. 1437 CERTIFIED ARCHITECT		COMMONWEALTH OF VIRGINIA CARL D. CRESS, JR. CERTIFICATE NO. 937 CERTIFIED ARCHITECT	

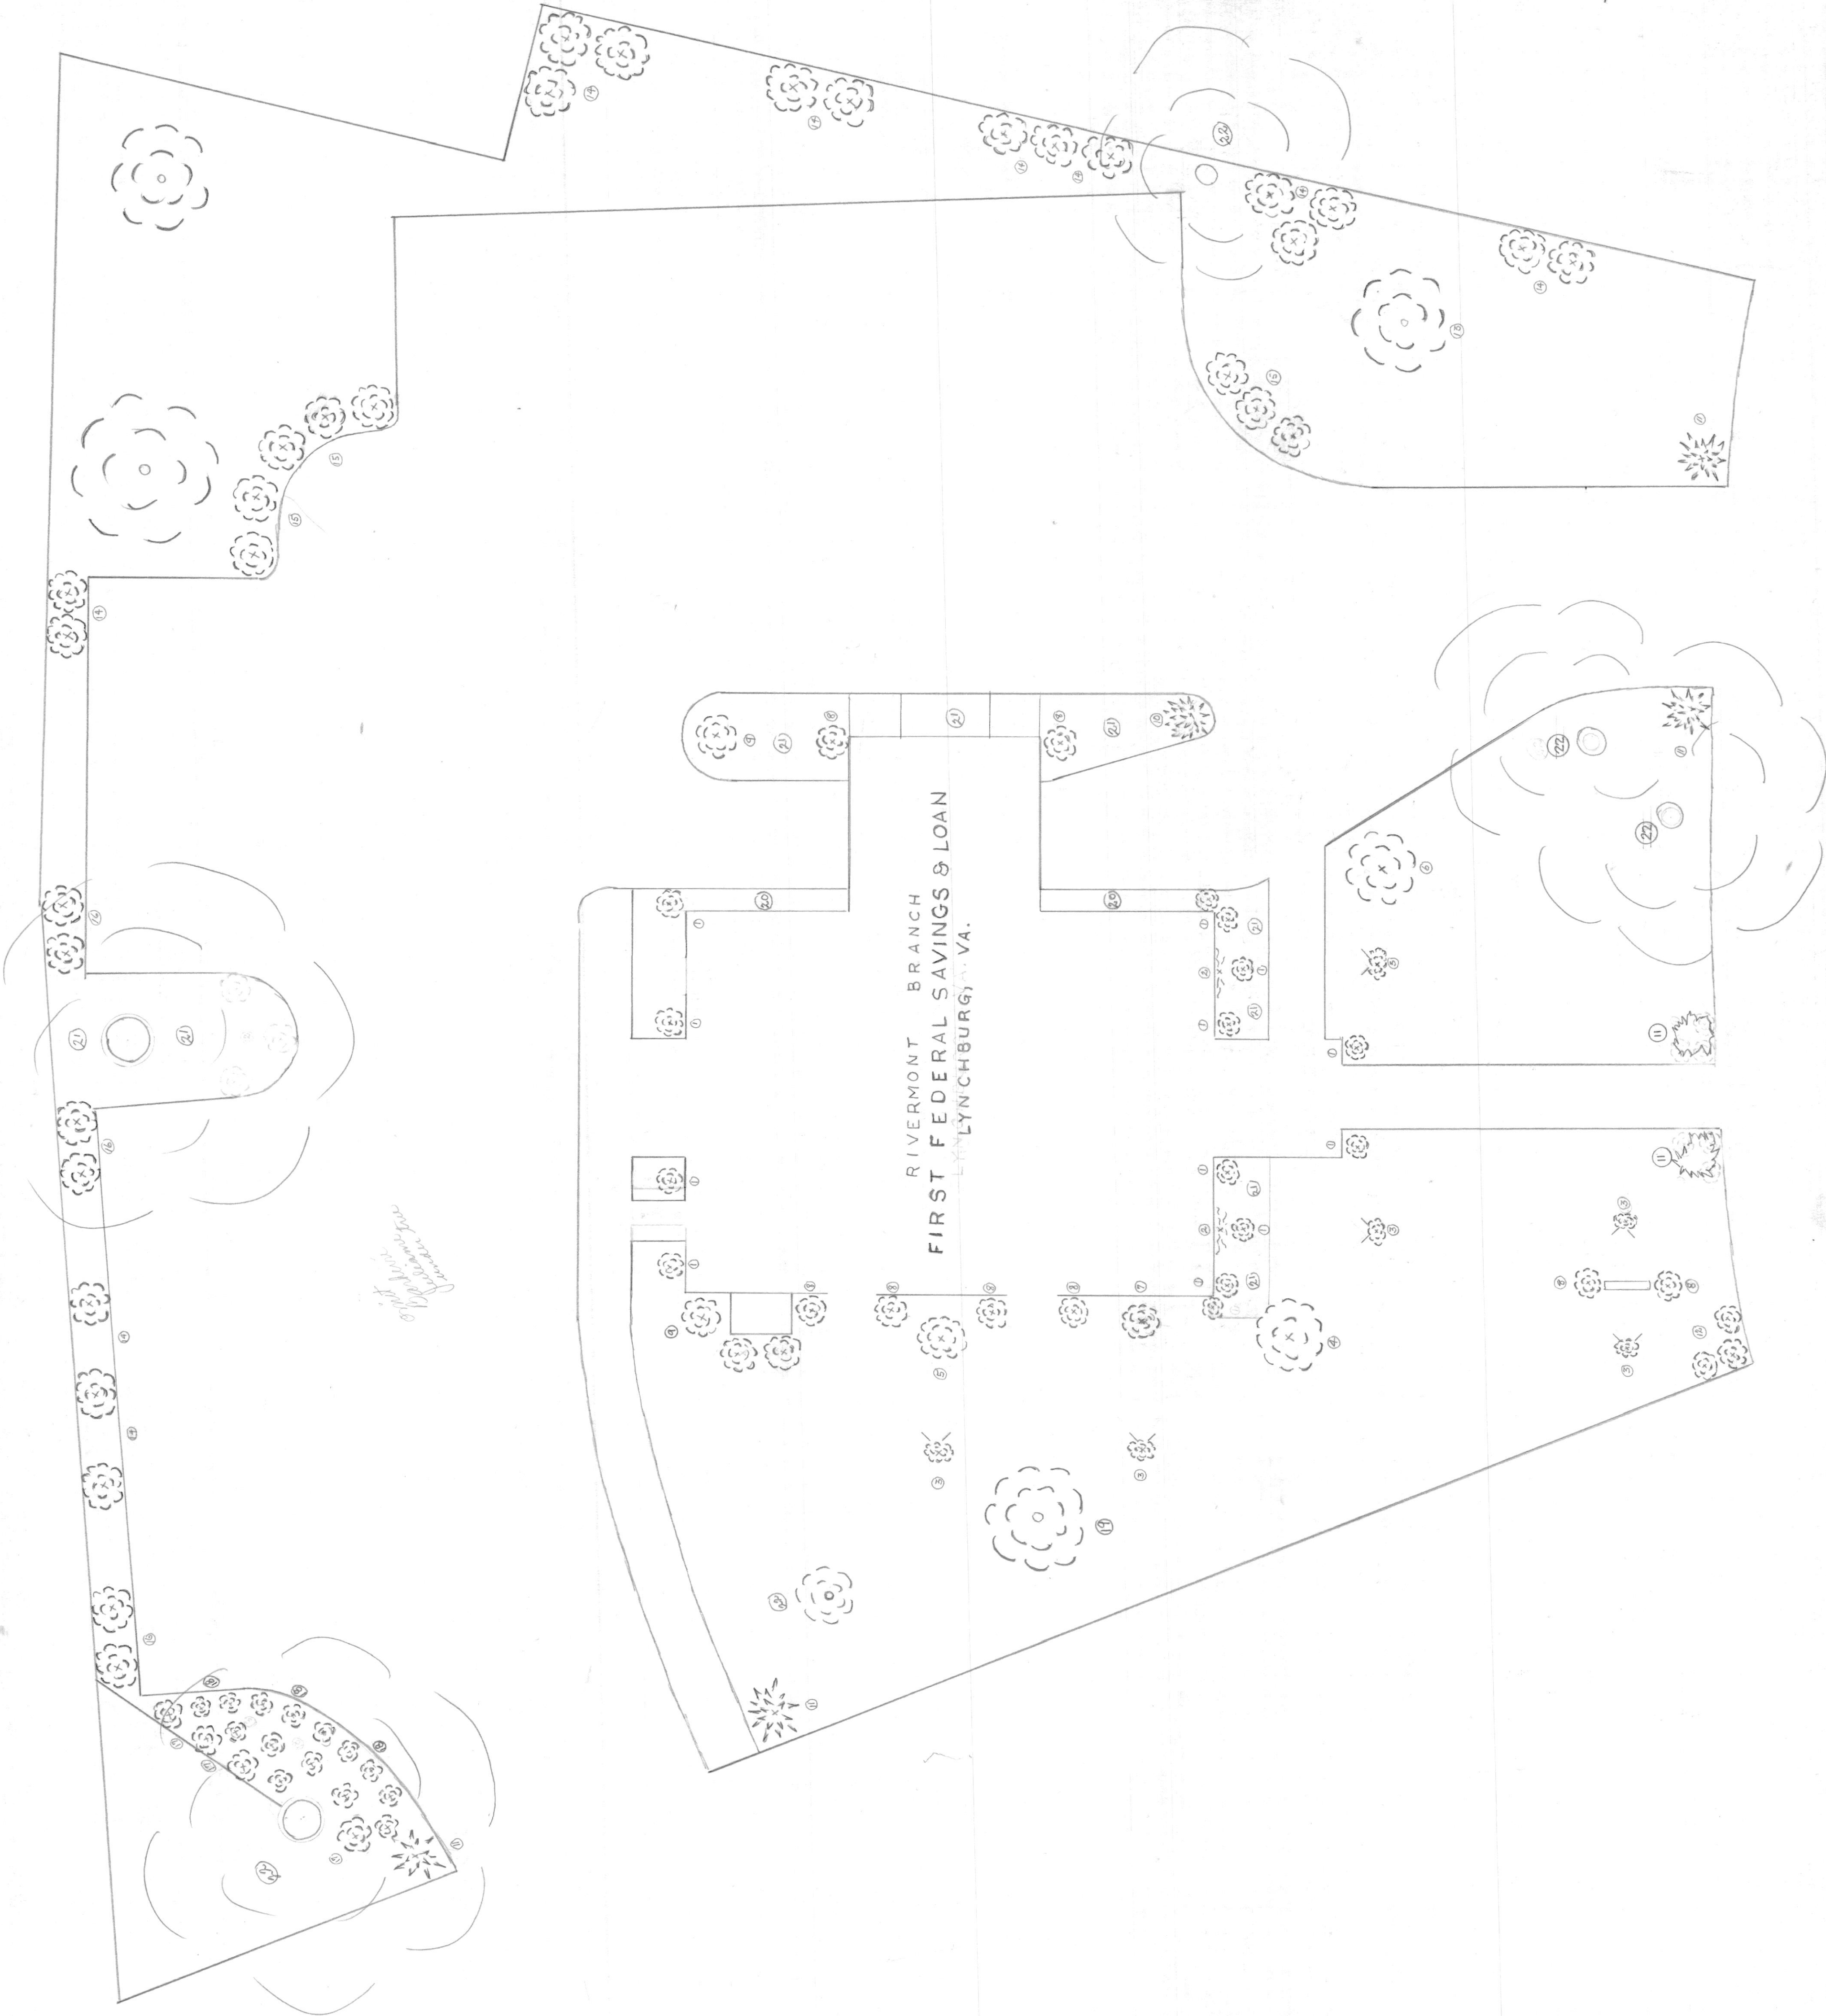

1. English Boxwood *	20'-24"	20	*
2. Camelia-Sasanqua	24'-30"	2	*
3. Pine - Mugho	12'-14'	6	*
4. Cherry - Weeping	6'	1	*
5. Crepe Myrtle	4'-5'	1	*
6. Dogwood - white	5'-6'	1	*
7. Viburnum - Carles	2'-3'	1	*
8. Burfordi holly - dwarf	18'-20"	6	*
9. Osmanthus - Fortunei	24'-30"	2	*
10. Juniper - Blue rug	12'-14"	3	*
11. Juniper - Nicks compacta - **	24'-30"	4	*
12. Barberry - Tulliane	18'-24"	3	*
13. Magnolia - Grandiflora	6'-7'	1	*
14. Flowering shrubs - mixed	24'-30"	18	*
15. Forsythia	3'-5'	7	*
16. Quince - Japanica	18'-24"	6	*
17. Rhododendron	15'-18"	4	*
18. Azaleas	10'-12"	14	*
19. Maple - sugar	8'-10'	1	*
20. English Ivy - bed	700 sq ft. 100	40	*
21. Periwinkle (Vinca Minor) - bed			*
22. Existing trees			*

* Boxwood has been purchased - bidder is to dig and trans-plant only. - Plants now at 3889 Royal Blvd -
** Spreading Yews may be substituted -
All plants, trees and beds to be mulched 1/2" deep with pine bark.

ALL PLANTING & MULCHING TO BE PERFORMED IN ACCORDANCE WITH RECOMMENDATIONS OF THE AMERICAN NURSERYMEN'S ASSOC.


LANDSCAPE PLAN

-BY-


LUNSFORD L. LOVING

Landscape Designer & Consultant

LYNCHBURG, VA

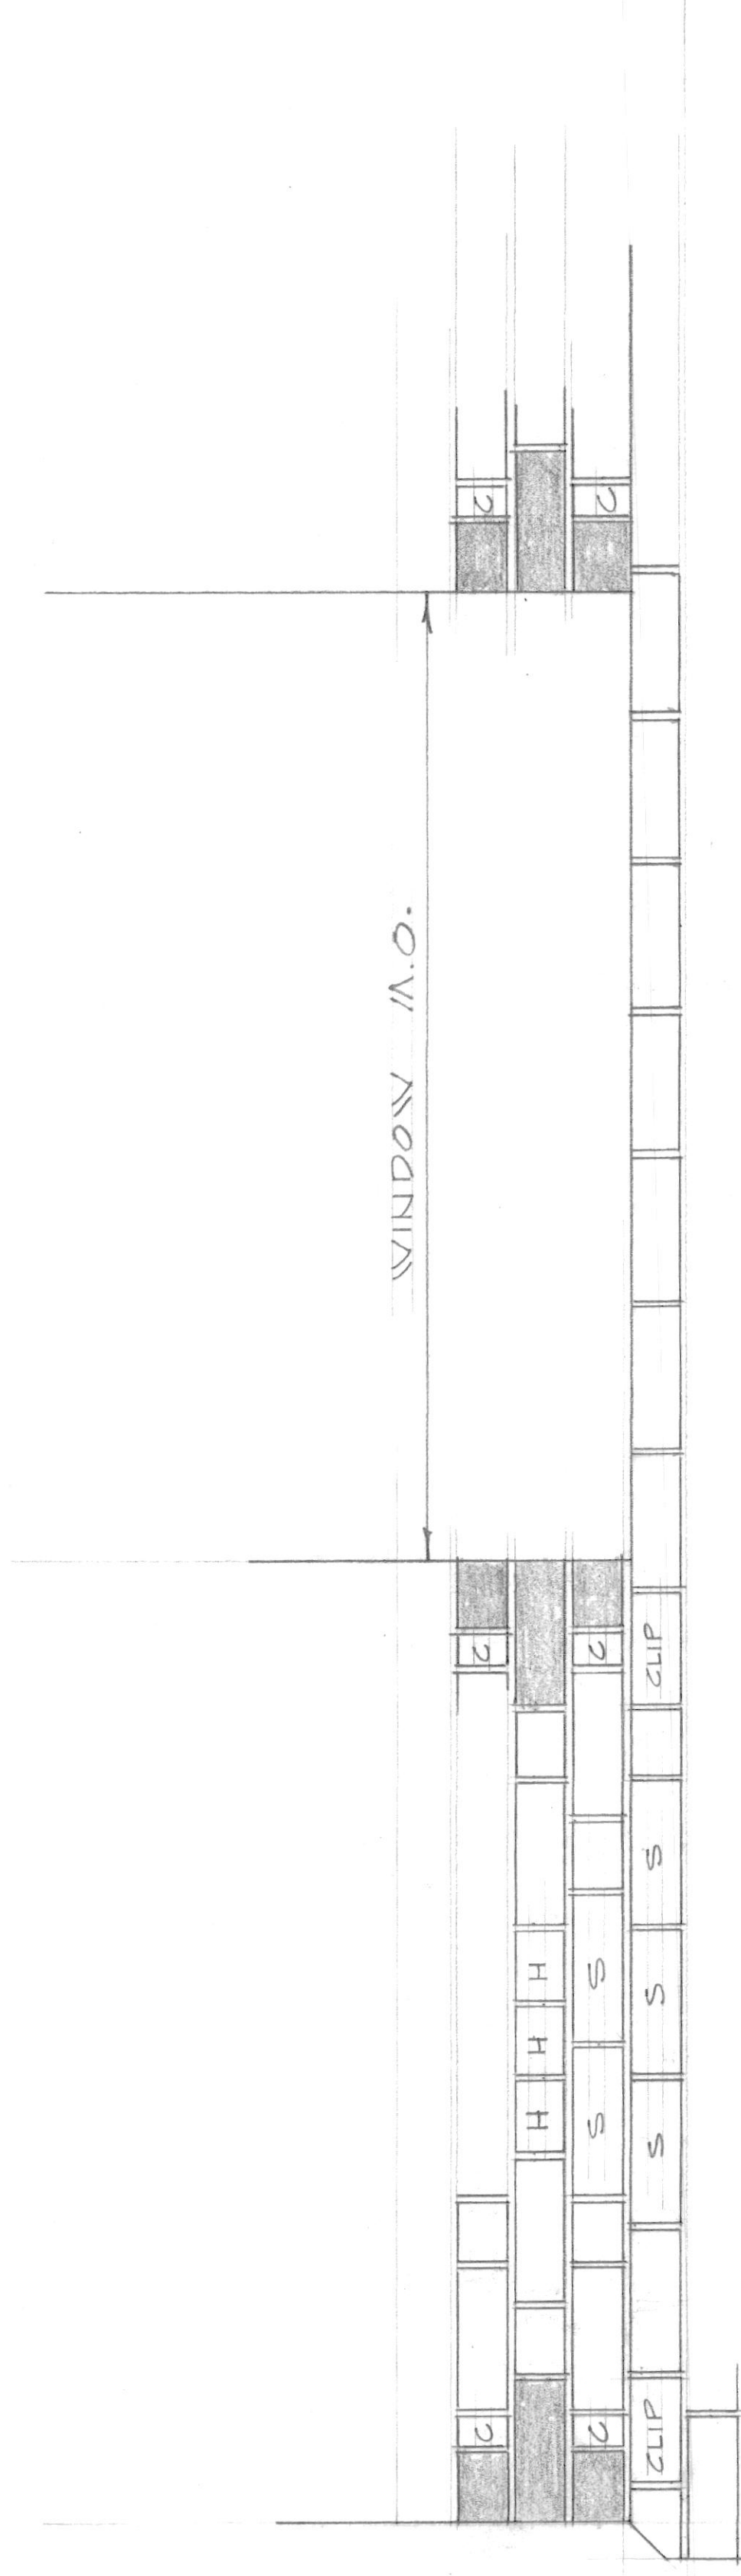

REAR ELEV.

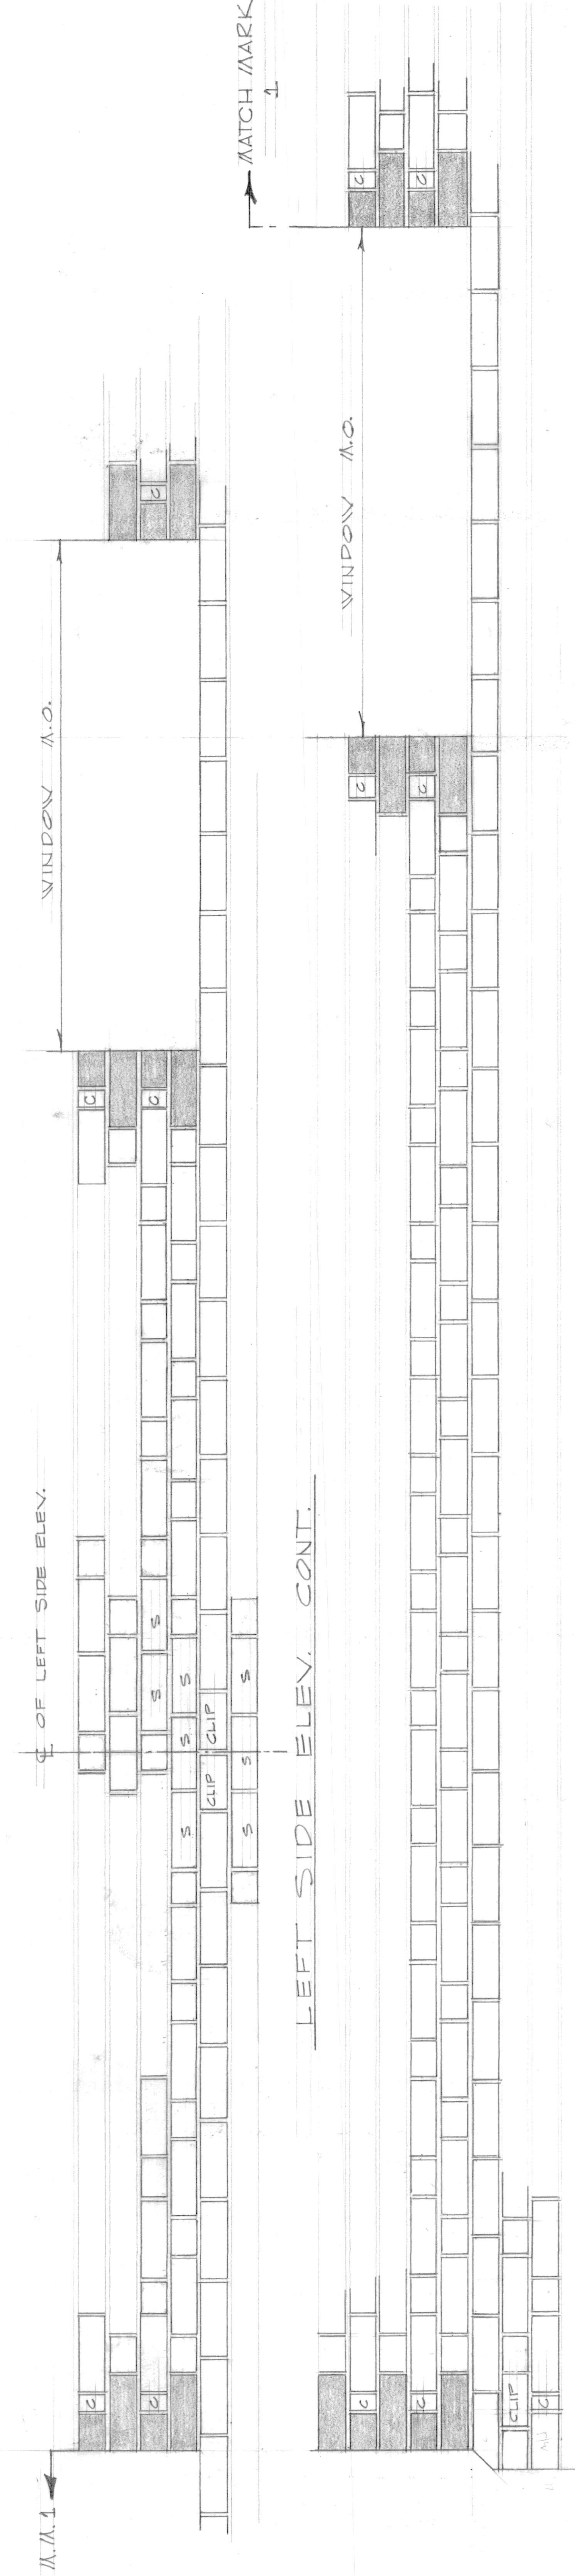



LEFT SIDE ELEV. CONT.

LEFT SIDE ELEVATION
SCALE 1/2" = 1'-0"

RIVERMONT BRANCH
FIRST FEDERAL SAVINGS LOAN
LYNCHBURG, VA

LANDSCAPE PLAN
-BY-
LUNSFORD L. LOVING
Landscape Designer & Consultant
LYNCHBURG, VA.

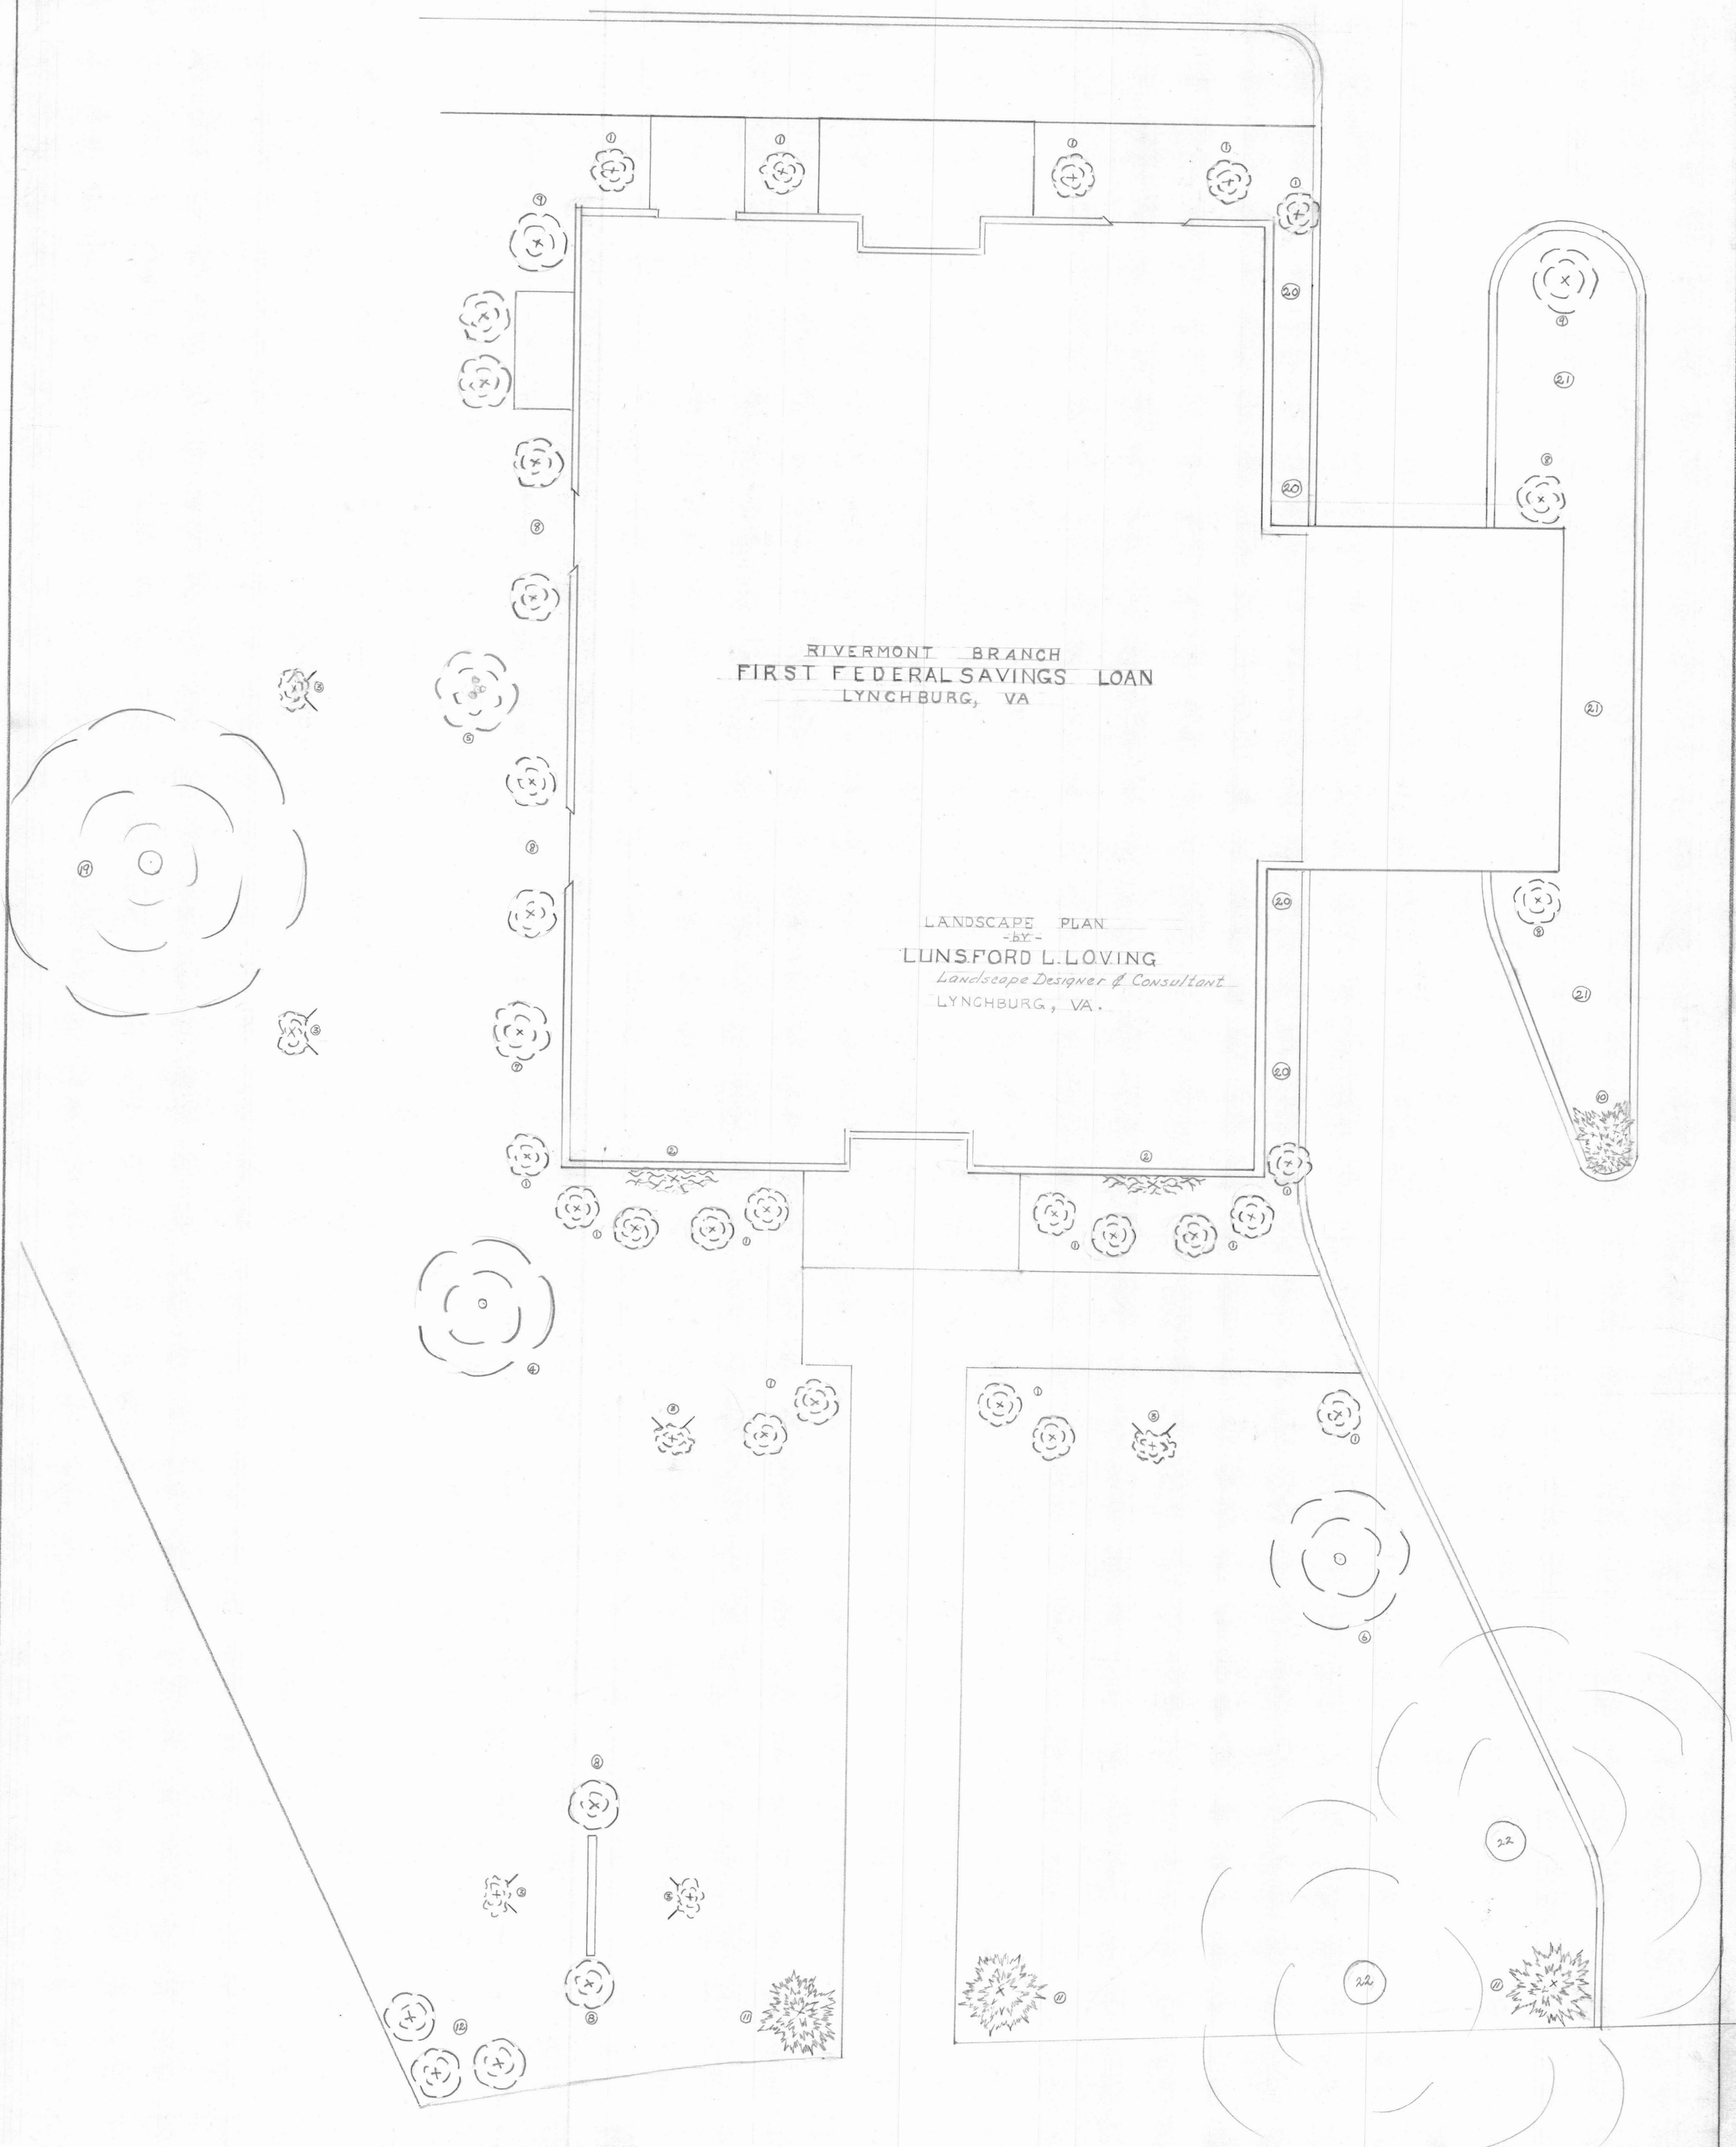

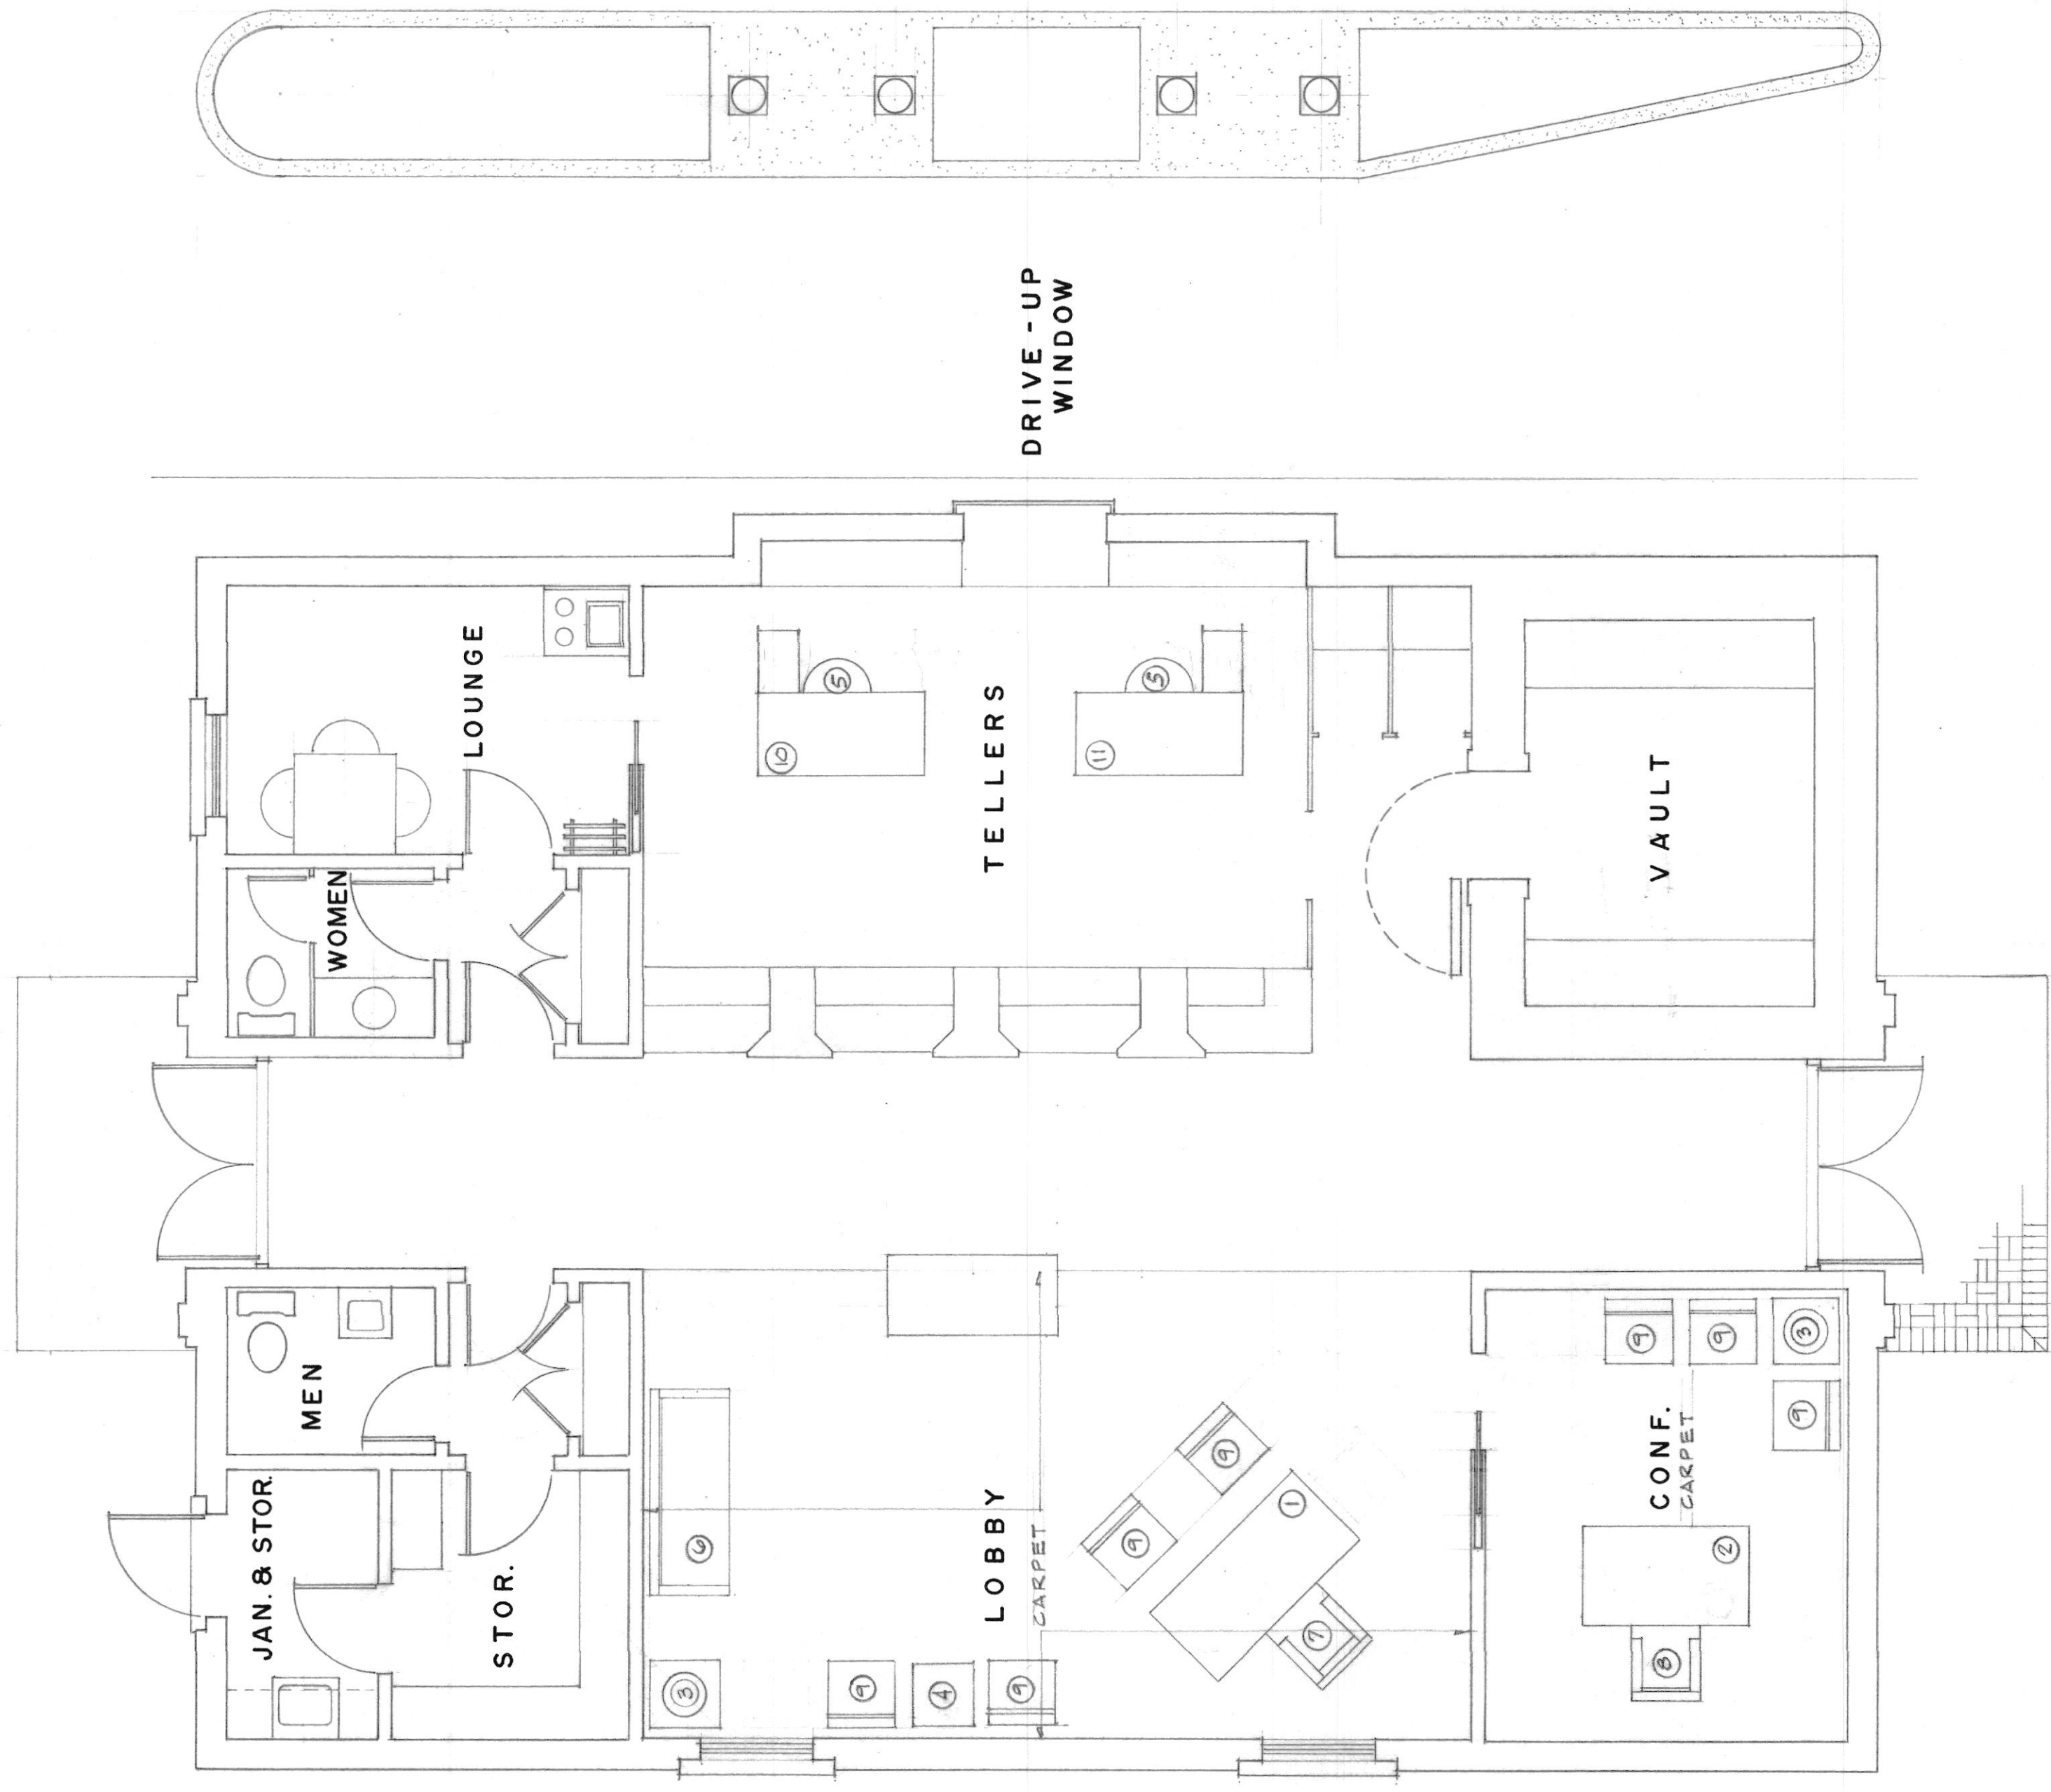

FLOOR PLAN 1/4" = 1'-0"

FURNITURE PLAN

CRESS - RHODES & ASSOCIATES ARCHITECTS 714 COURT STREET, LYNCHBURG, VIRGINIA		SHEET NO 1	
RIVERMONT BRANCH FIRST FEDERAL SAVINGS & LOAN LYNCHBURG, VA.		DATE 5 NOV. 71	CHECKED OF 1
CONG. NO. 7110	DATE 5 NOV. 71	DRAWN	CHECKED

COMMONWEALTH OF VIRGINIA
WILLIAM L. RHODES
CERTIFICATE NO.
1437
REGISTERED ARCHITECT

COMMONWEALTH OF VIRGINIA
GUY A. CRESS, JR.
CERTIFICATE NO.
937
REGISTERED ARCHITECT

LIGHTING FIXTURE SCHEDULE

TYPE	MANUFACTURER	CATALOG NO.	LAMPS		REMARKS
			NO	TYPE	
A	FURNISHED BY CLG CONTR		6	30W-R5	RECESSED FIXTURE FURNISHED TO ELEC. INSTALL BY ELEC.
B	ART METAL	W-1001	2	75W-A19	WALL 6 1/2" MTG. HEIGHT
C	SMITHCRAFT	MTIFCL240CM180	2	40W-WRS	RECESSED
D	SMITHCRAFT	1x4MD1VA2-40	2	40W-WRS	SURFACE
E	SMITHCRAFT	MT2FHA2URCN/20	2	40W-L	RECESSED
F	HADCO	B-2127	1	100W-1F	WALL FINISH #7 HE VERDE
G	AL-KCO	332H-SW	1	F80 T12/RS	SURFACE MOUNT IN COUNTER, SW NEAR END OF FIXTURE
H	LIGHTOLIER	7280	1	150W R40	RECESS POSITION TO LIGHT HALLTOWNE
J	ART METAL	GOJ	2	60W 1F	SURFACE
K	PASS & SEYMOUR	AL 3140	1	100W-1F	SURFACE
L	ART METAL	30-1030 WS	1	300W-1F	RECESSED
M	LIGHTOLIER	7860	1	100W-A19	RECESSED
N	STONCO	150-L	1	150 PAR38/SP	MATTE WHITE
P	AL-KCO	315-L-SW	1	15 W-T5	MOUNT IN COUNTER, SW NEAR END OF FIXTURE


NOTE-A: REFER TO SITE PLAN FOR OUTSIDE LIGHT FIXTURES
LOCATIONS. ALL SHALL BE INSTALLED BY TRAIL LIGHTING
WITH APPROVAL BY ARCHITECT

LIGHTING PANEL-LA									
TYPE	QO	240/120	- 14	- 3W	- SW	185A	- MLO	REMARKS	
CIR.	WATTS	CIRCUIT BREAKER	NO	AMPS	NO	SIZE	CONDUCTOR	CONV.	REMARKS
1	1300	1	20	2	#12	3/4"	LIGHTING		
2	1680								
3	1260								
4	1800								
5	1260								
6	1080								
7	1800								
8	720								
9	1440								
10	720								
11	1440								
12	720								
13	1440								
14,16	8A EACH	1	20	2	#12	3/4"	COMPUTER POWER		
15,17									EXT. LIGHTS
18-24									SPACE ONLY

POWER PANEL-PA									
TYPE	NQ08	240/120	- 34	- 4W	A	- 400 A	MAIN BREAKER	REMARKS	
CIR.	HP OR LOAD WATTS	NO.	AMPS	NO.	AMPS	NO.	SIZE	CONV.	REMARKS
1	5 KW	15.7	2	30	2	#10	5/4"		DOMESTIC WATER MTR.
2	1/4 HP	5.8	1	20	2	#12			DRINKING FOUNTAIN
3	HERM.	25.8	5	40	3	#8			HEAT PUMP OUTSIDE UNIT
4	1250	11.4	1	20	2	#12			WH3
5	1250	11.4	1	20	2	#12			WH1
6	1/2 HP + STEM	6	1	20	2	#12			EXH. FAN + EER-1
7	1250	11.4	1	20	2	#12			WH2
8	23.5 KW		3	100	3	#2	1 1/4"		EDC-1
9	2 KW	8.8	2	20	2	#12	3/4"		EDC-2
10	2 KW	8.8	2	20	2	#12			EDC-3
11	2 KW	8.8	2	20	2	#12			CLG. CAB. MTR.
12			2	100	3	#2	1 1/4"		LIGHTING PNL LA
13	8 KW	36.3	2	50	3	#6	1"		RANGE

NOTE-B:
EXTERIOR POST LAMPS, SIGN LIGHTS &
BUILDING FLOOD LIGHTS SHALL BE ON
PHOTOCELL ON-TIME OFF, TIME CLOCK CIRCUIT

POST LAMP
LIGHT - HADCO MODEL - MVL-6088 "TILE ARCHITECTURAL"
195 IV-MERCURY VAPOR, 175-185-A INTEGRAL BALLAST
120 VOLTS
POST - 1200, 9'-0" HIGH, NO. 9 HR VERDE FINISH - COMPLETE
LADDER RST - #6-5, NO 9 HR VERDE FINISH
FDM - ELECTRICAL CONTRACTOR TO PROVIDE CONCRETE BASE
5'-0" INTO EXIST. EARTH, SIZE AS REQ'D. BY MFG.

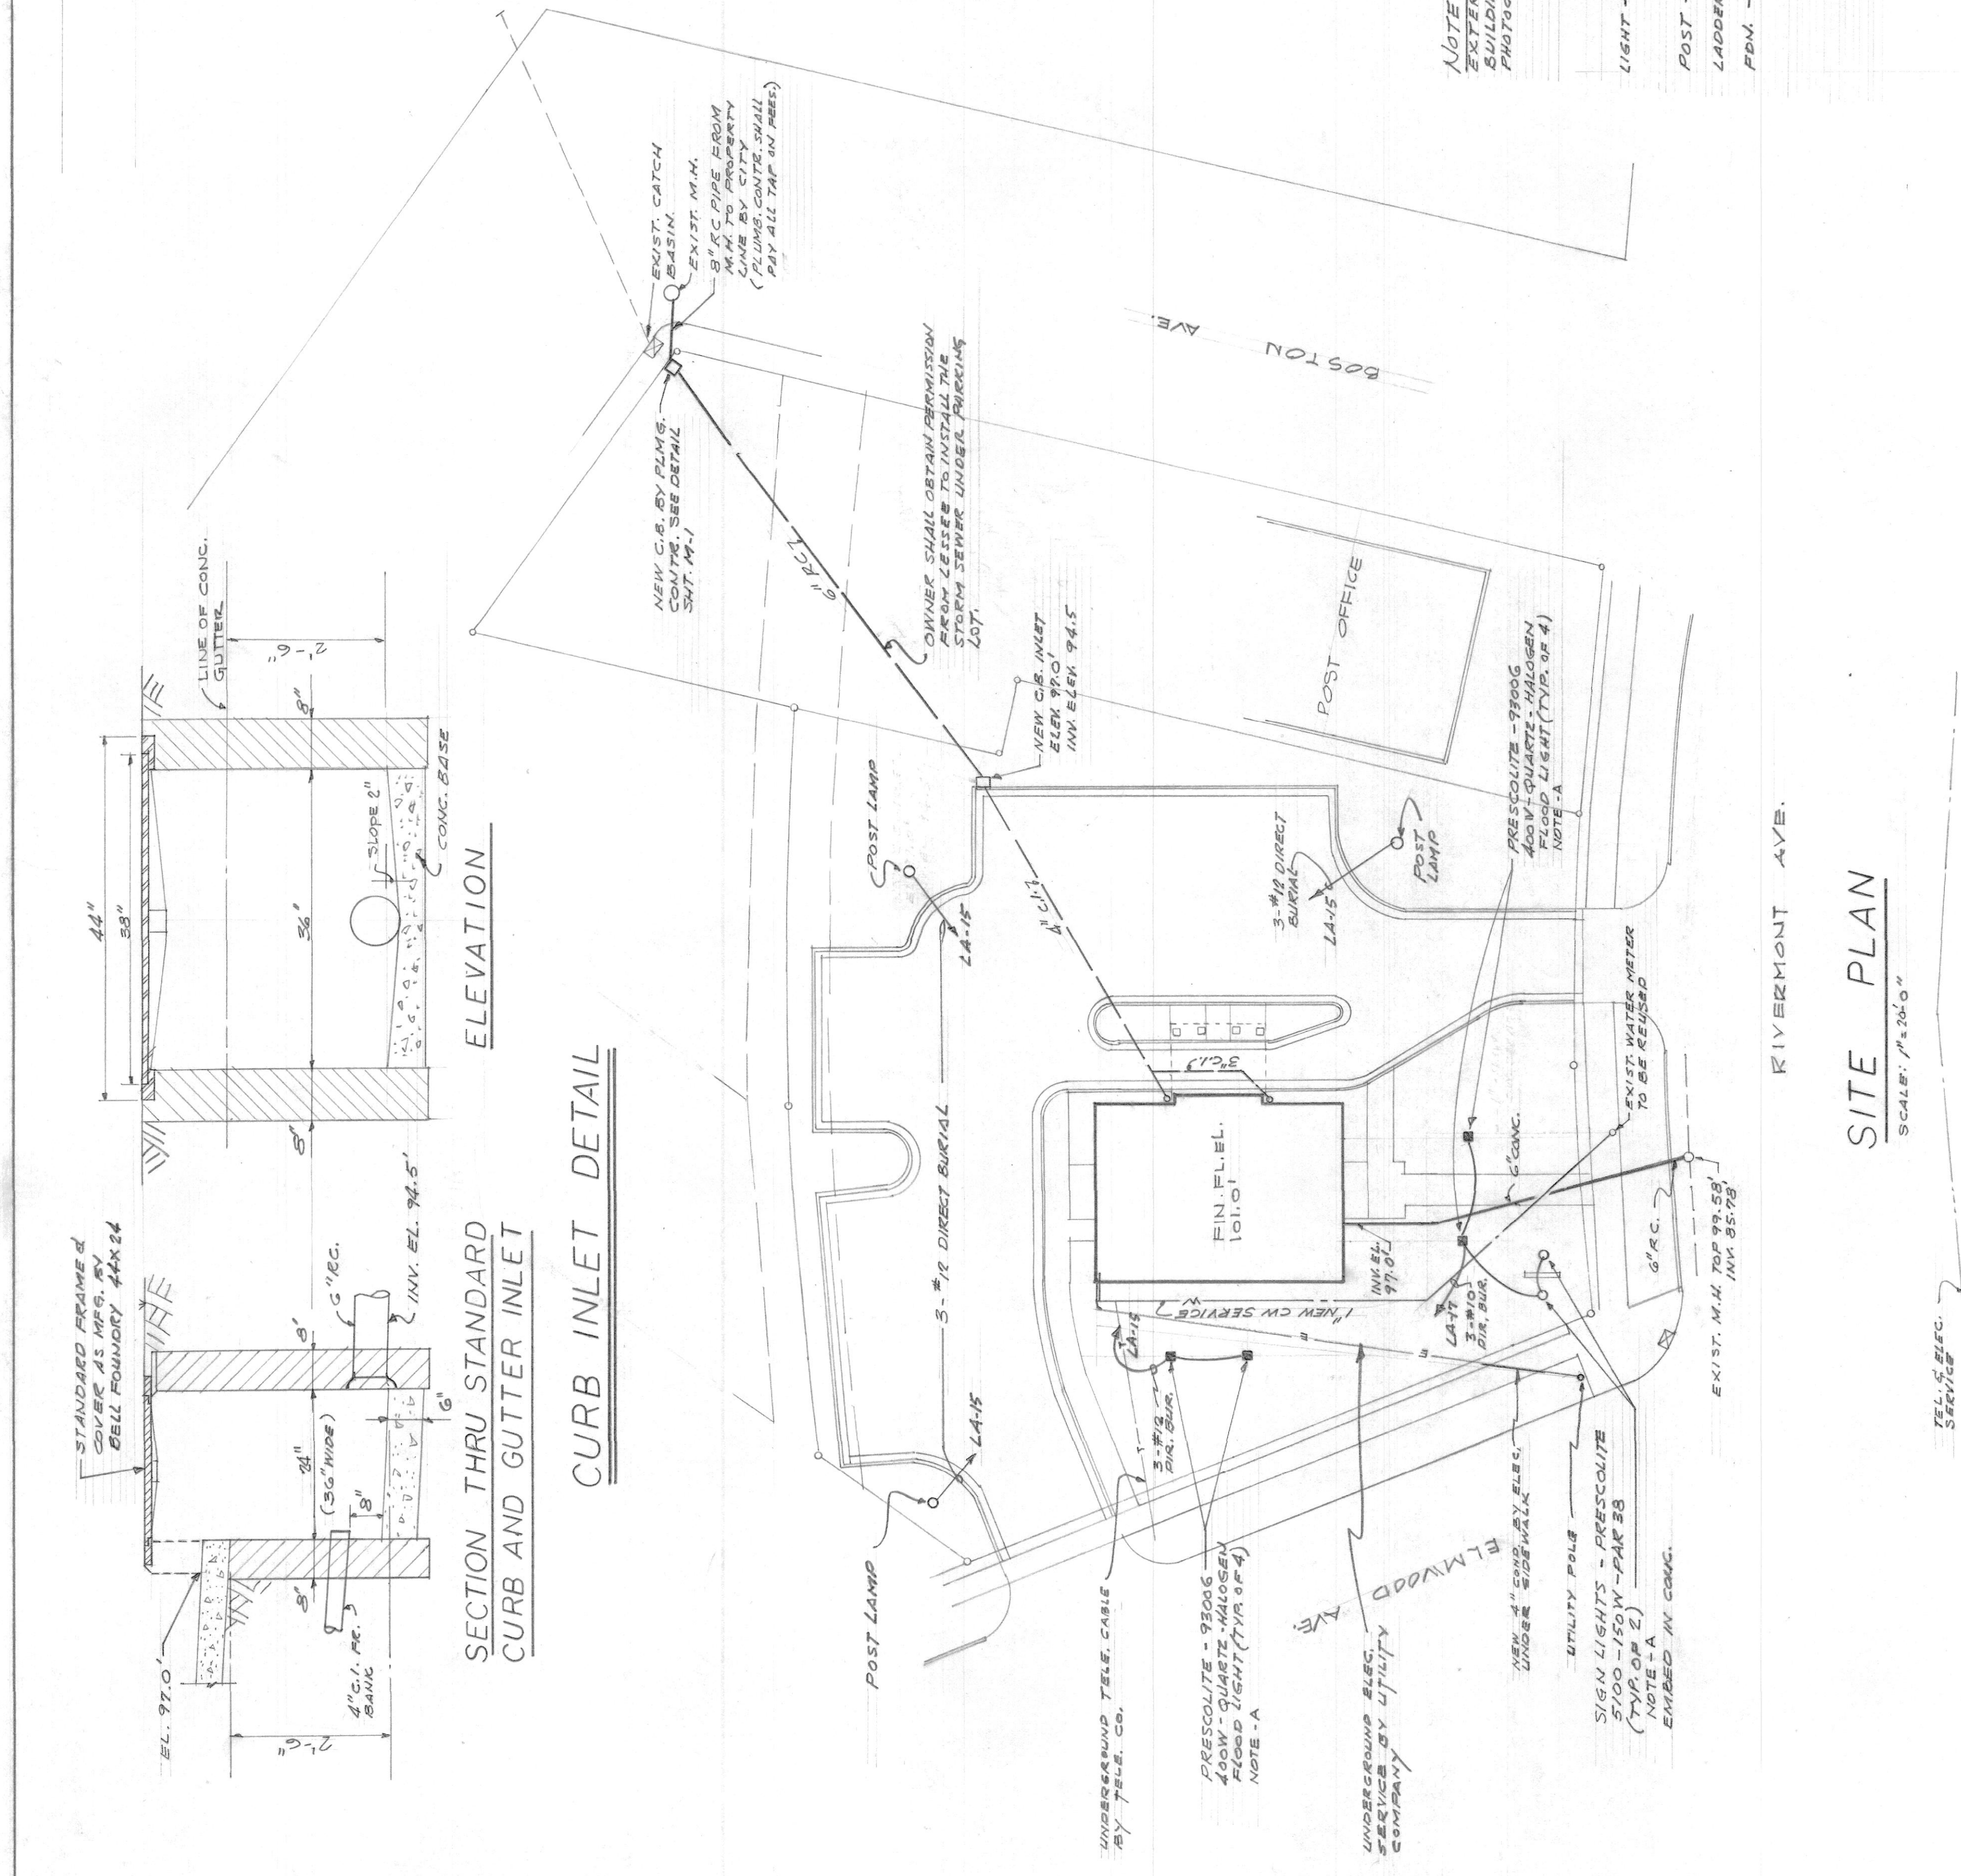

UTILITY PLAN & DETAILS

COMMONWEALTH OF VIRGINIA
ENGINEER
M. LYMAN JOHNSON
CERTIFICATE NO. 96
15110000

COMMONWEALTH OF VIRGINIA
ARCHITECTS
CRESS - RHODES & ASSOCIATES
714 COURT STREET, LYNCHBURG, VIRGINIA

COMMONWEALTH OF VIRGINIA
ARCHITECTS
CRESS - RHODES & ASSOCIATES
714 COURT STREET, LYNCHBURG, VIRGINIA


RIVERMONT BRANCH
FIRST FEDERAL SAVINGS & LOAN
LYNCHBURG, VA.

DATE: 11/11/81
DRAWN: M.L.J.
CHECKED: M.L.J.
11/11/81

11/11/81
11/11/81
11/11/81

SHEET NO. U-1
OF 1

NOTE:
ALL WASTE PIPING INSTALLED BEL. FLOOR.
ALL WASTE PIPING INSTALLED BEL. FLOOR.
ALL DOMESTIC WATER PIPING INSTALL ABV. CLG.
COORDINATE PIPING WITH DUCT WORK.

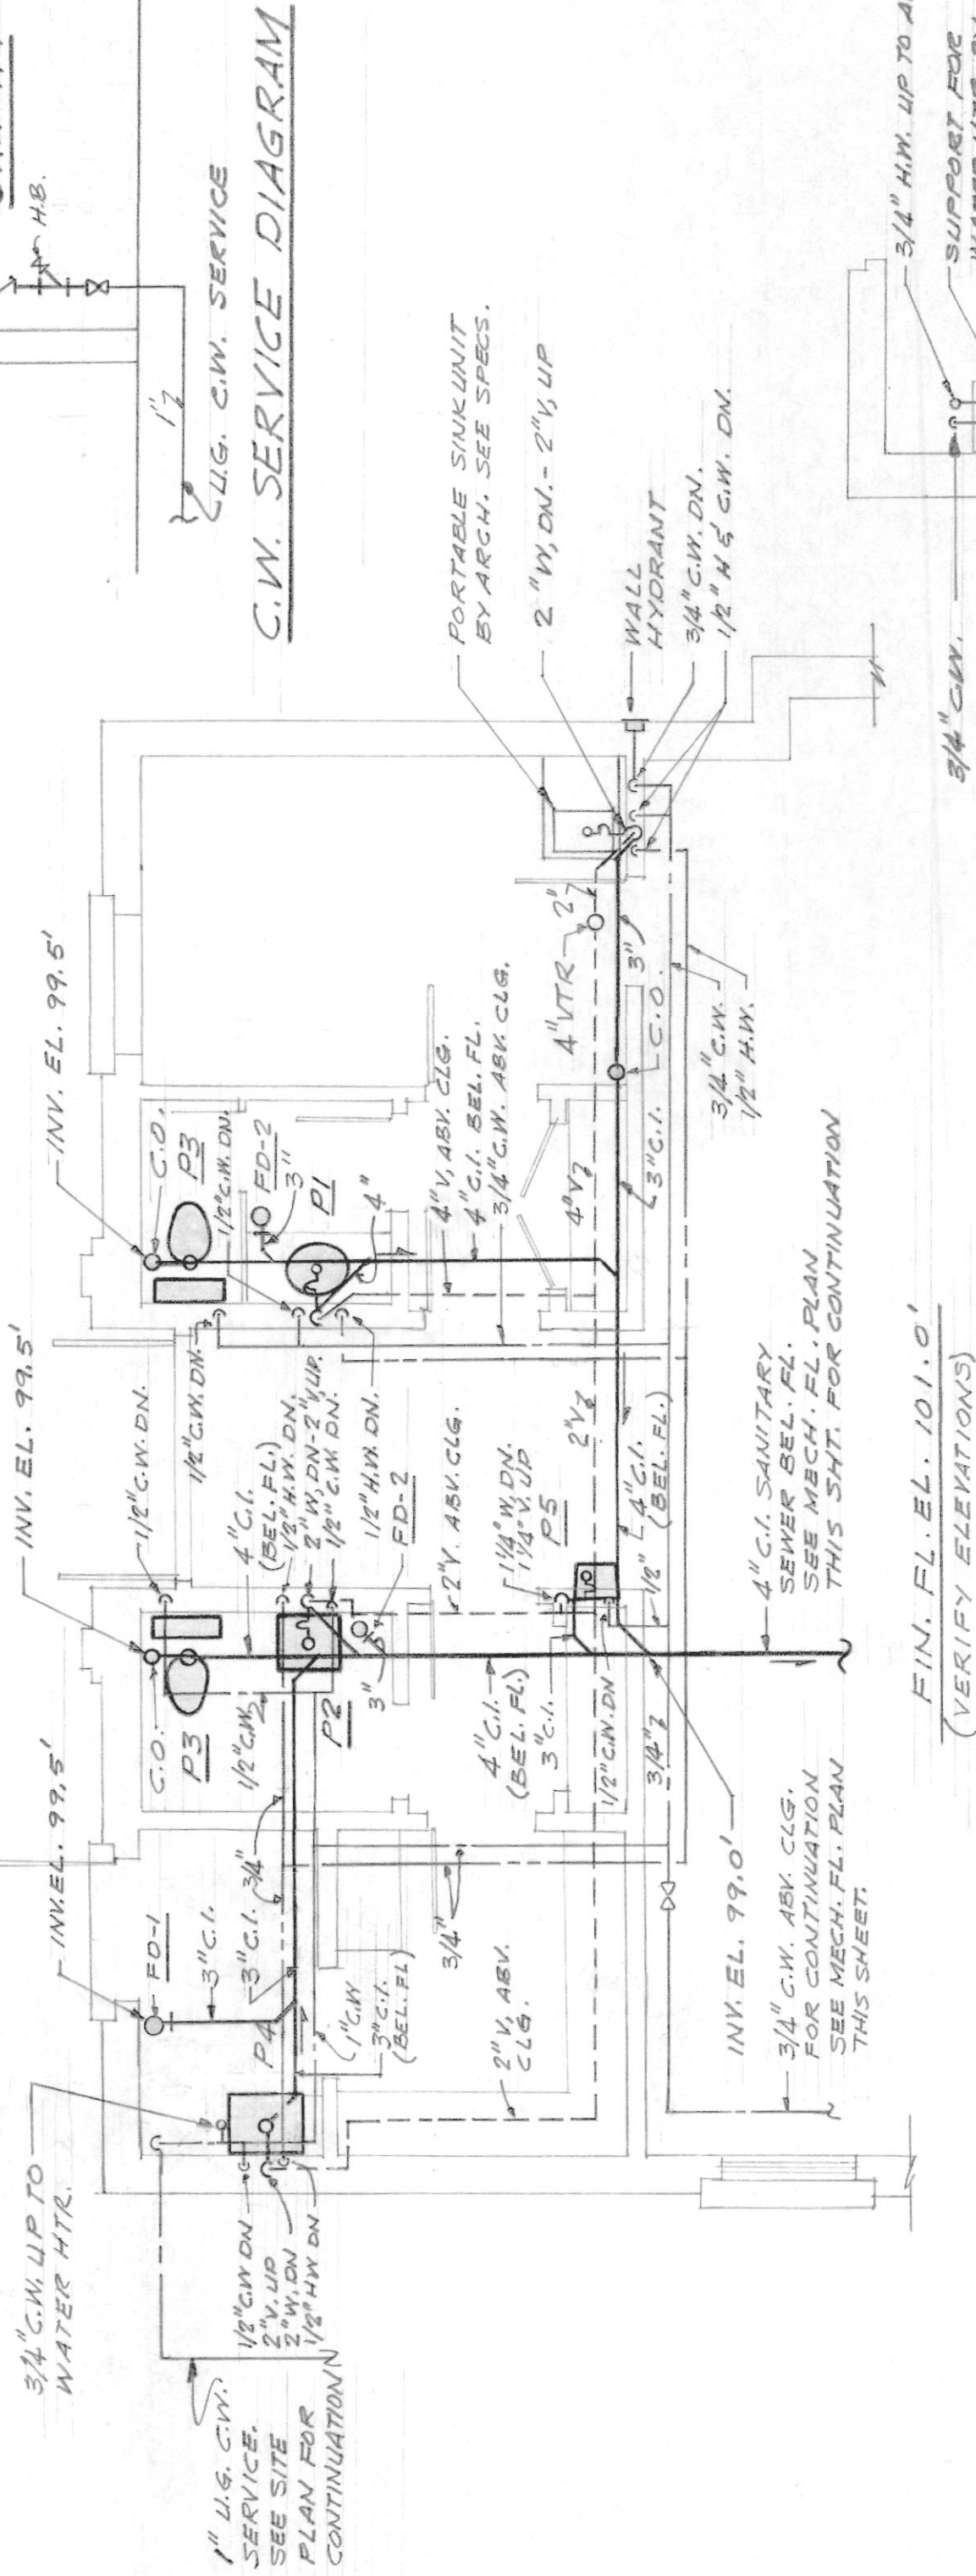

PARTIAL PLUMBING FLOOR PLAN
SCALE: 1/4" = 1'-0"


PARTIAL FLOOR PLAN FOR WATER HTR.

PLUMBING FIXTURE SCHEDULE						
MARK	MANUFACTURER CATALOG NO.	TRIM	H.W.	C.W.	TRAP OR OUTLET CONN. HEIGHT	REMARKS
P1	AMERICAN STANDARD VANETTE-3003.506	2121.267	1/2"	1/2"	441/8 O.B.	19" EVANSEL C.I. SELF-RIMMING
P2	AMERICAN STANDARD DECLYN-0361.075	2121.267	1/2"	1/2"	441/8 O.B.	31" TO VIT. CHINA - WALL HANGING 19X17
P3	AMERICAN STANDARD CADET-2109.056	CHURCH SEAT 395	1/2"	1/2"	4"	ELONG. SIPHON VET VIT. CHINA
P4	FIAT-MSB 2424	FAUCET #980-44	1/2"	1/2"	1 1/2"	BRACKET #980A4-30° DOME STRAINER
P5	OASIS-ODP55	-	-	1/2"	1 1/4"	RECESS-20 1/2" COLOR BY ARCH. TO OUTLET FURN. TRAP

* PLUMBING CONTRACTOR SHALL FURNISH CHROME R SUPPLY & STOPS TO FIXTURES
NOT FURNISHED WITH SUPPLY PIPING. FURNISH TRAPS OF SAME MATERIAL-2064. OF
SIZE SPECIFIED.

FLOOR DRAINS


FD-1C 1/2" SAM - 7003 FED. C.I. BODY, S.C. TRAP, C.I. LAGGAGE STRAINER
FD-2C 1/2" SAM - 303-36 SSP, C.I. BODY, C.I. TRAP, NIKALLOY STRAINER

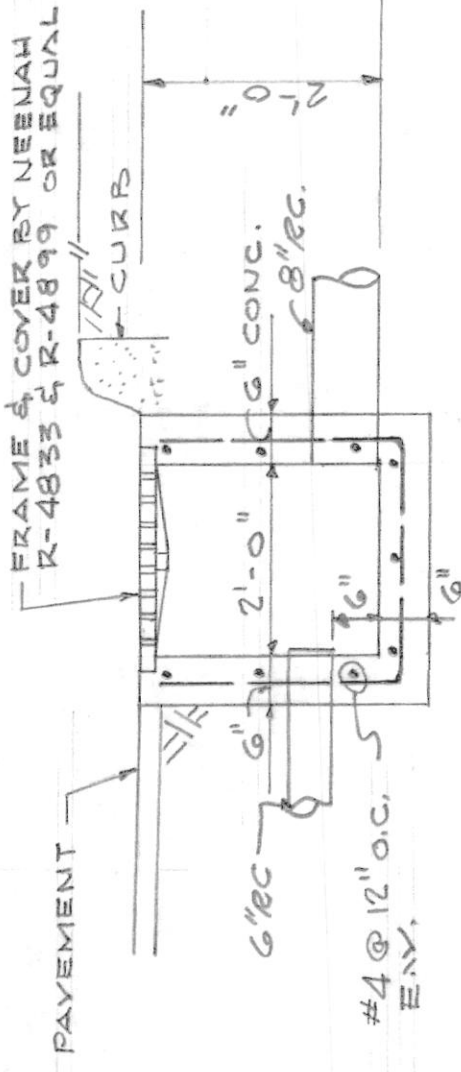

TYPICAL CATCH BASIN DETAIL

LEGEND

- SANITARY WASTE
- SANITARY VENT
- COLD WATER
- HOT WATER
- PIPE TURNING UP
- PIPE TURNING DOWN
- GATE VALVE
- CHECK VALVE
- STRAINER W/ HOSE END
- AFR ABOVE FINISHED FLOOR
- M.T. MOUNTING HEIGHT
- C.D. CEILING DIFFUSER
- E.R. EXHAUST REGISTER (WITH O.B.D.)
- R.R. RETURN REGISTER (WITH O.B.D.)
- R.G. RETURN GRILLE (WITHOUT O.B.D.)
- C.I. CAST IRON
- C.O. CLEANOUT
- C.W. COLD WATER
- H.W. HOT WATER
- VTR. SANITARY VENT THRU ROOF
- W.H. WALL HYDRANT
- W. SANITARY WASTE
- V. SANITARY VENT
- RC REINFT. CONCRETE PIPE
- I.R. IN RAFTERS
- U.R. UNDER RAFTERS
- B.R. BETWEEN RAFTERS
- ⊕ THERMOSTAT 4'-6" A.F.F.

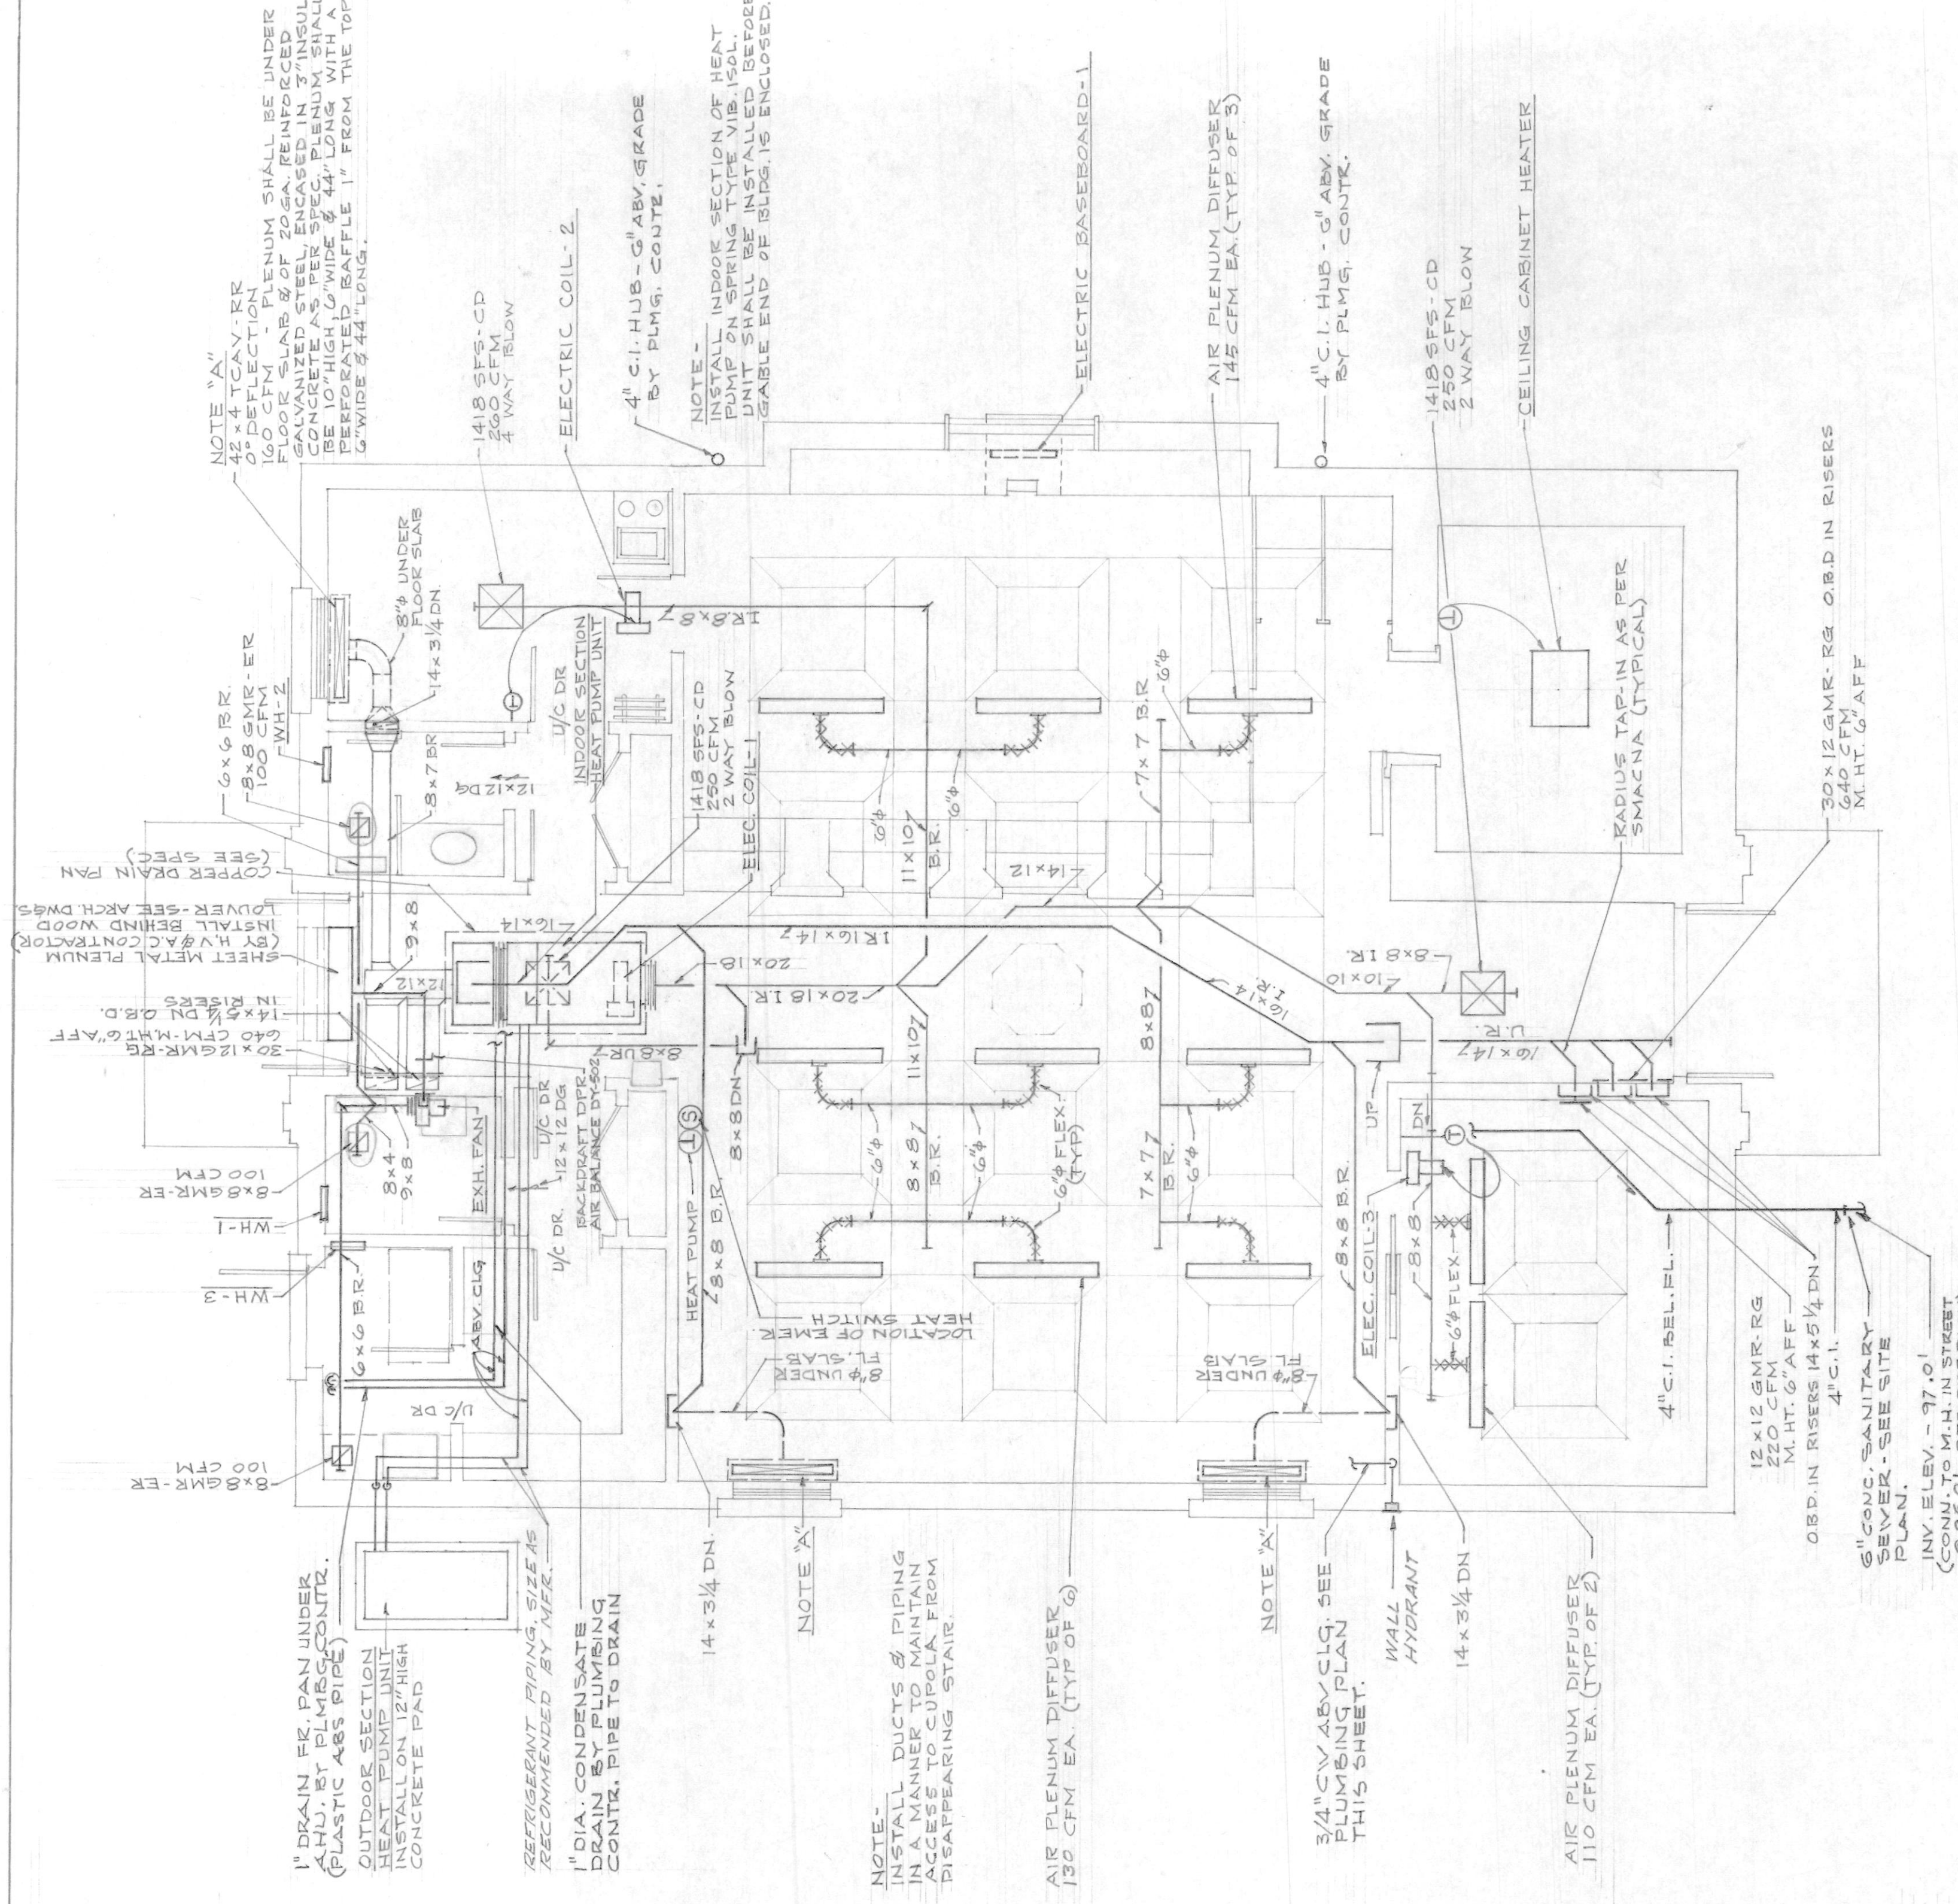

FLOOR PLAN
SCALE: 1/4" = 1'-0"


MECHANICAL - PLUMBING FLOOR PLANS & DETAILS

COMMONWEALTH OF VIRGINIA
ENGINEER
M. LYMAN JOHNSON
CERTIFICATE NO. 96
15110004
1437

COMMONWEALTH OF VIRGINIA
ARCHITECTS
CRESS - RHODES & ASSOCIATES
714 COURT STREET, LYNCHBURG, VIRGINIA
15110004
1437

RIVERMONT BRANCH
FIRST FEDERAL SAVINGS & LOAN
LYNCHBURG, VA.

SHEET NO. MP-1
DATE 12 NOV 71
DRAWN M.J.U.
CHECKED M.J.U.
OF 1

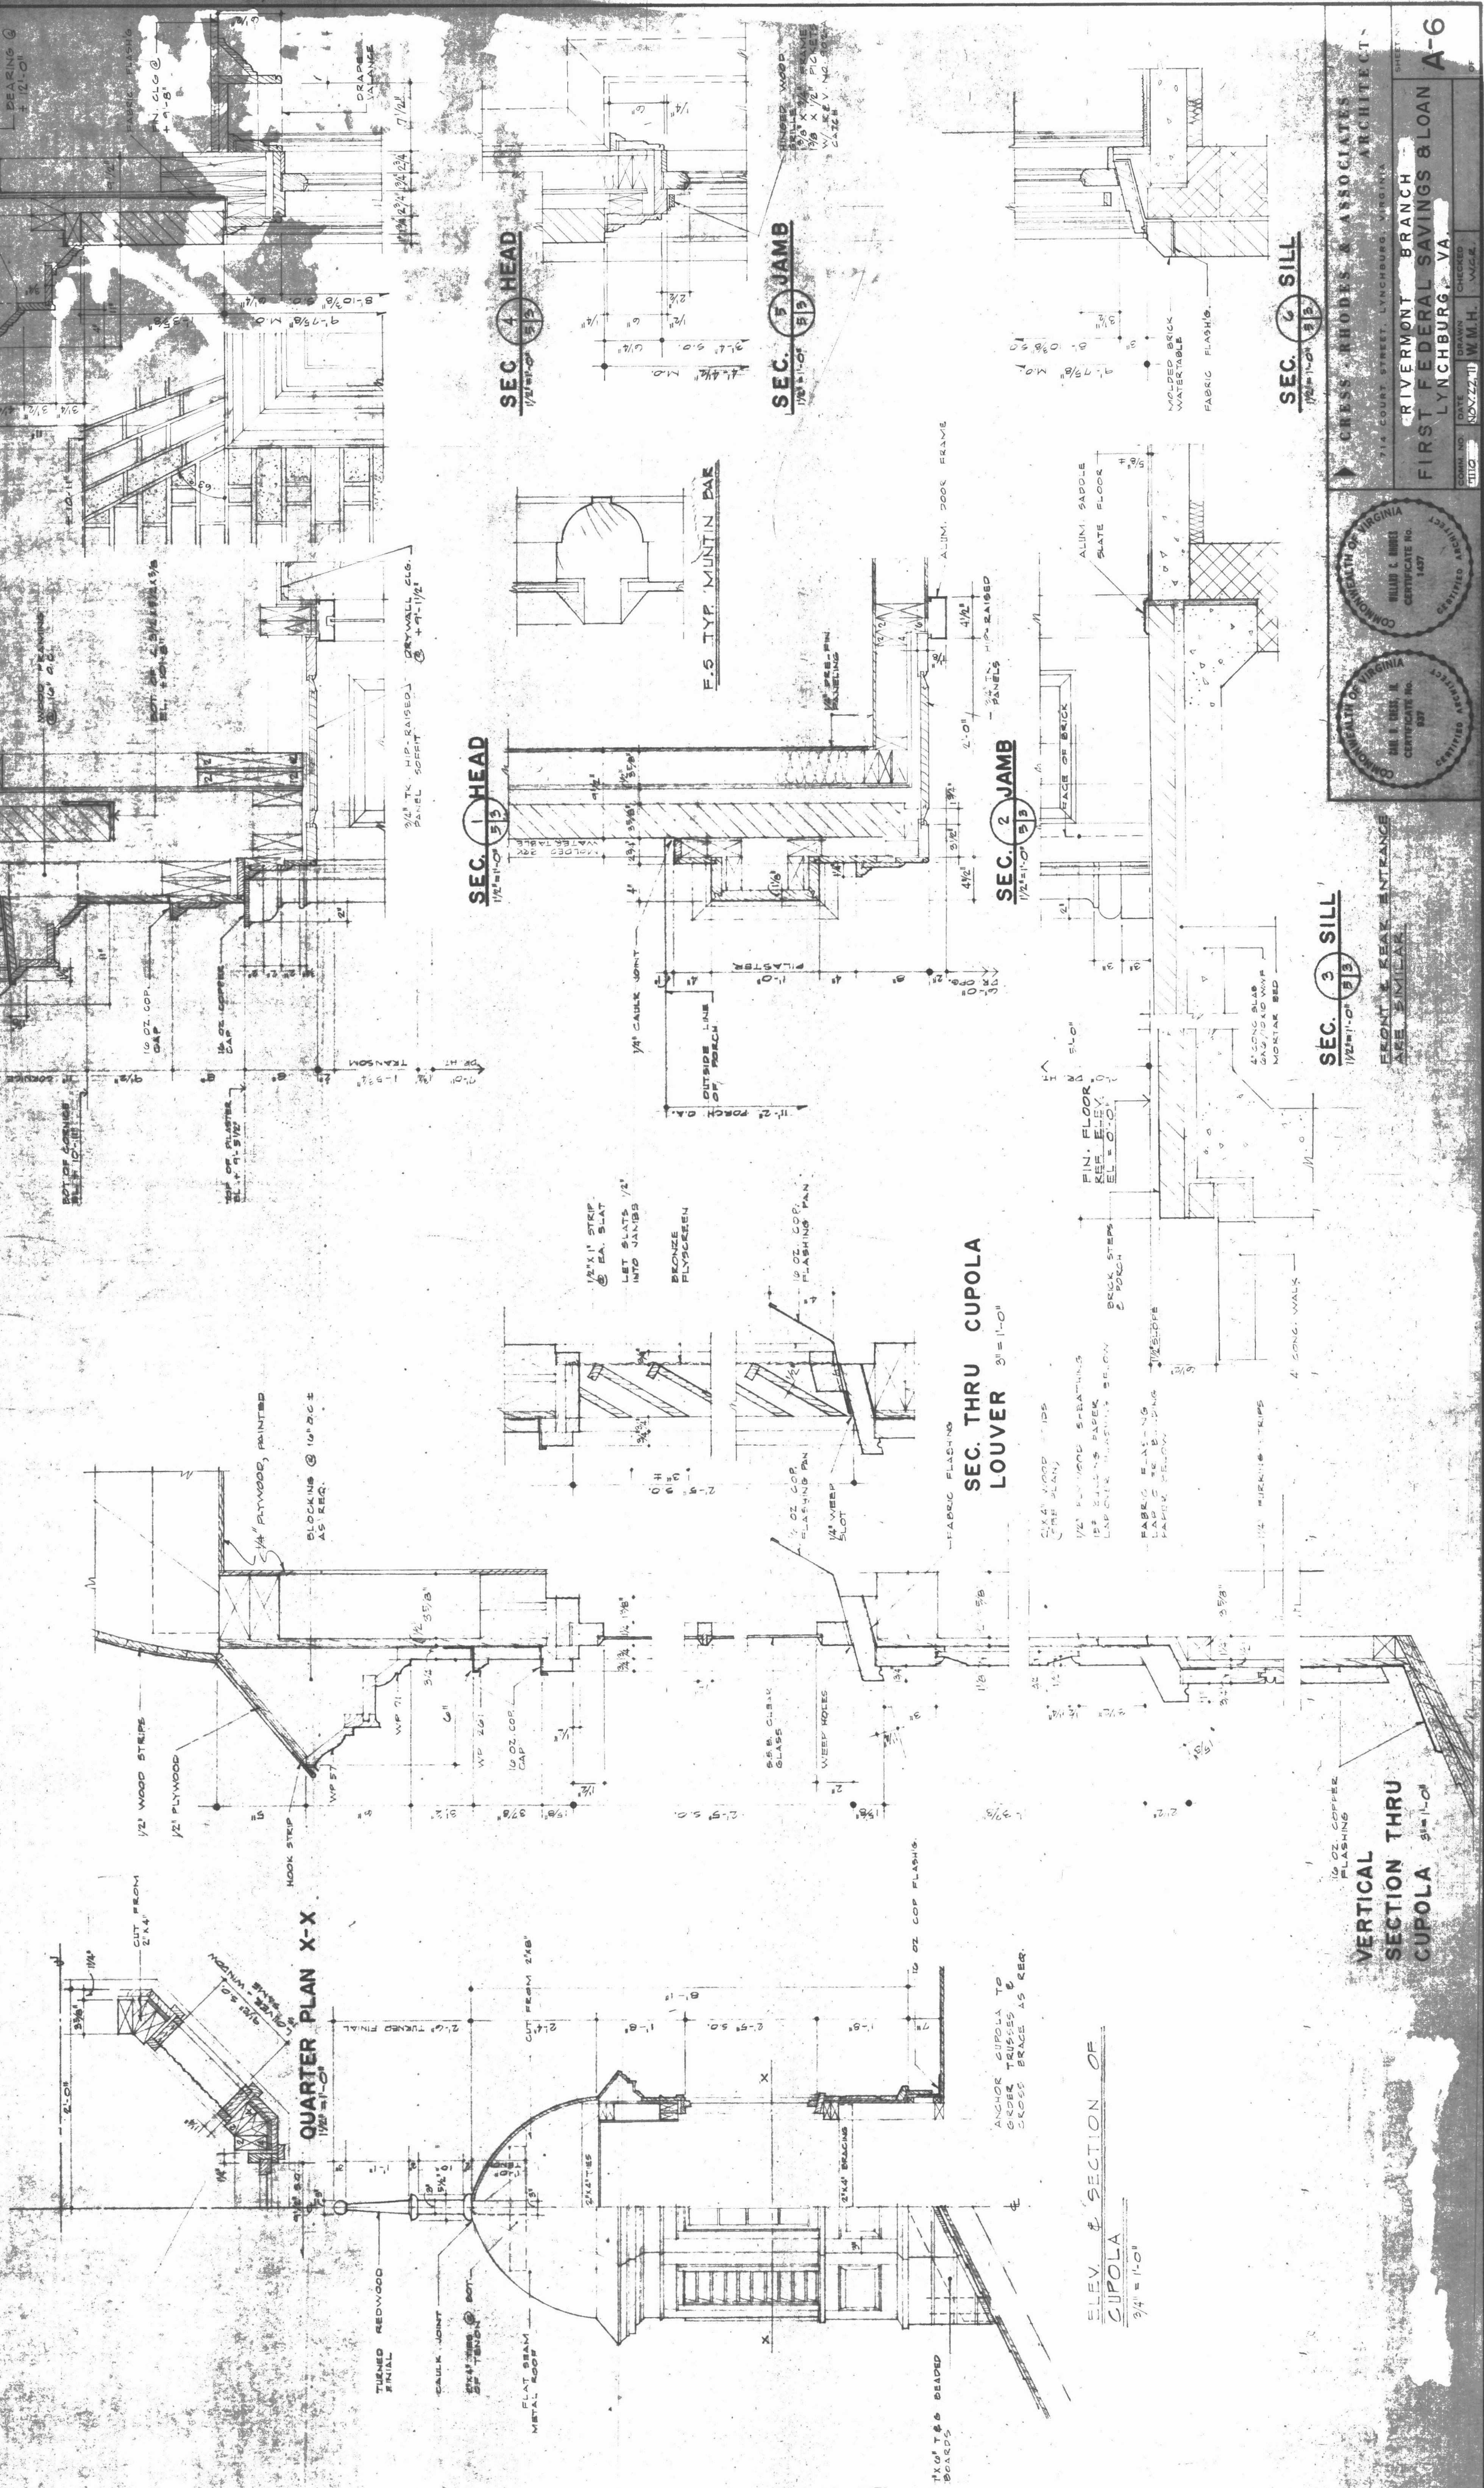

SEC. 3 SILL
1/2" x 1" x 10"
FRONT & REAR ENTRANCE
ARE SIMILAR

COMMONWEALTH OF VIRGINIA
WILLIAM C. JONES
CERTIFICATE No. 1437
1937
REGISTERED
ACCEPTEE

COMMONWEALTH OF VIRGINIA
WM. T. REED, JR.
CERTIFICATE No. 937
1937
REGISTERED
ACCEPTEE

7-10-12


CRESS, RHODES & ASSOCIATES
ARCHITECTS
714 COURT STREET, LYNCHBURG, VIRGINIA

RIVERMONT BRANCH
FIRST FEDERAL SAVINGS & LOAN
LYNCHBURG, VA

PROGRAM NO.	DATE	CHECKED	DATE	OF
110	NOV 22 1962	WMMH	WMMH	





SHEET 7

A-6

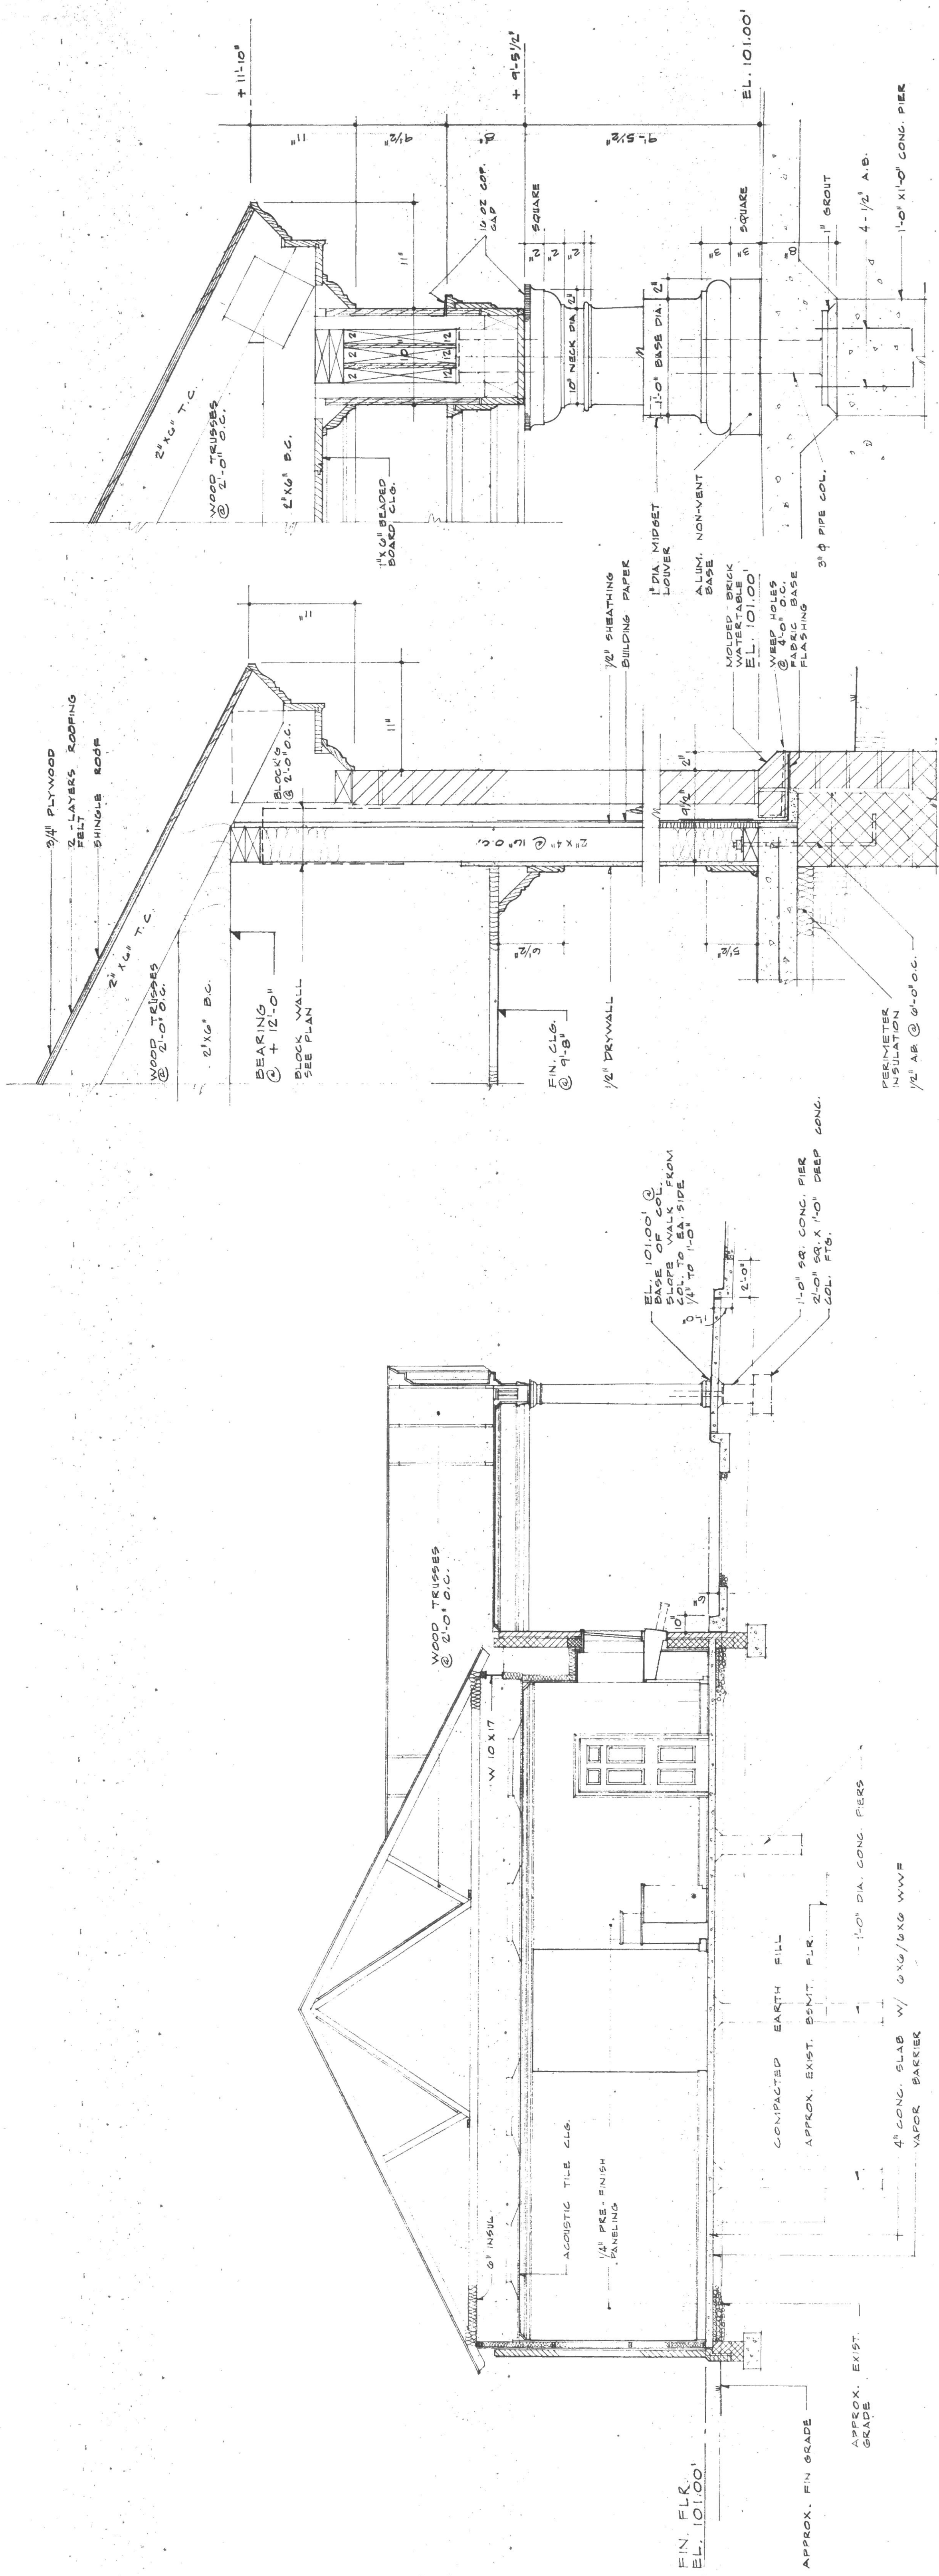


TYPICAL CROSS SECTION
 1/4" = 1'-0"

TYPICAL WALL SECTION
 1/2" = 1'-0"

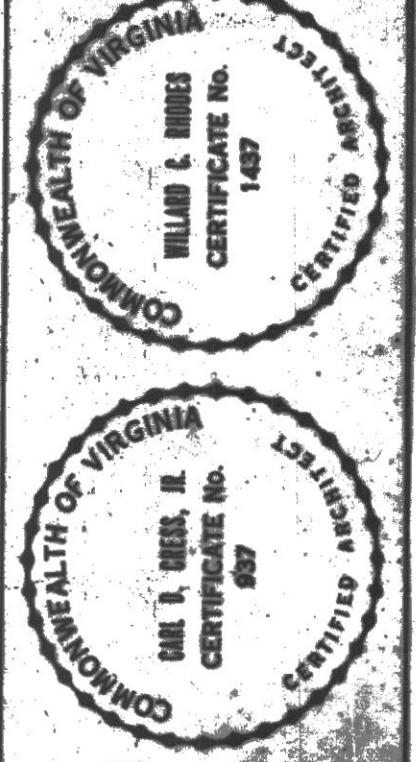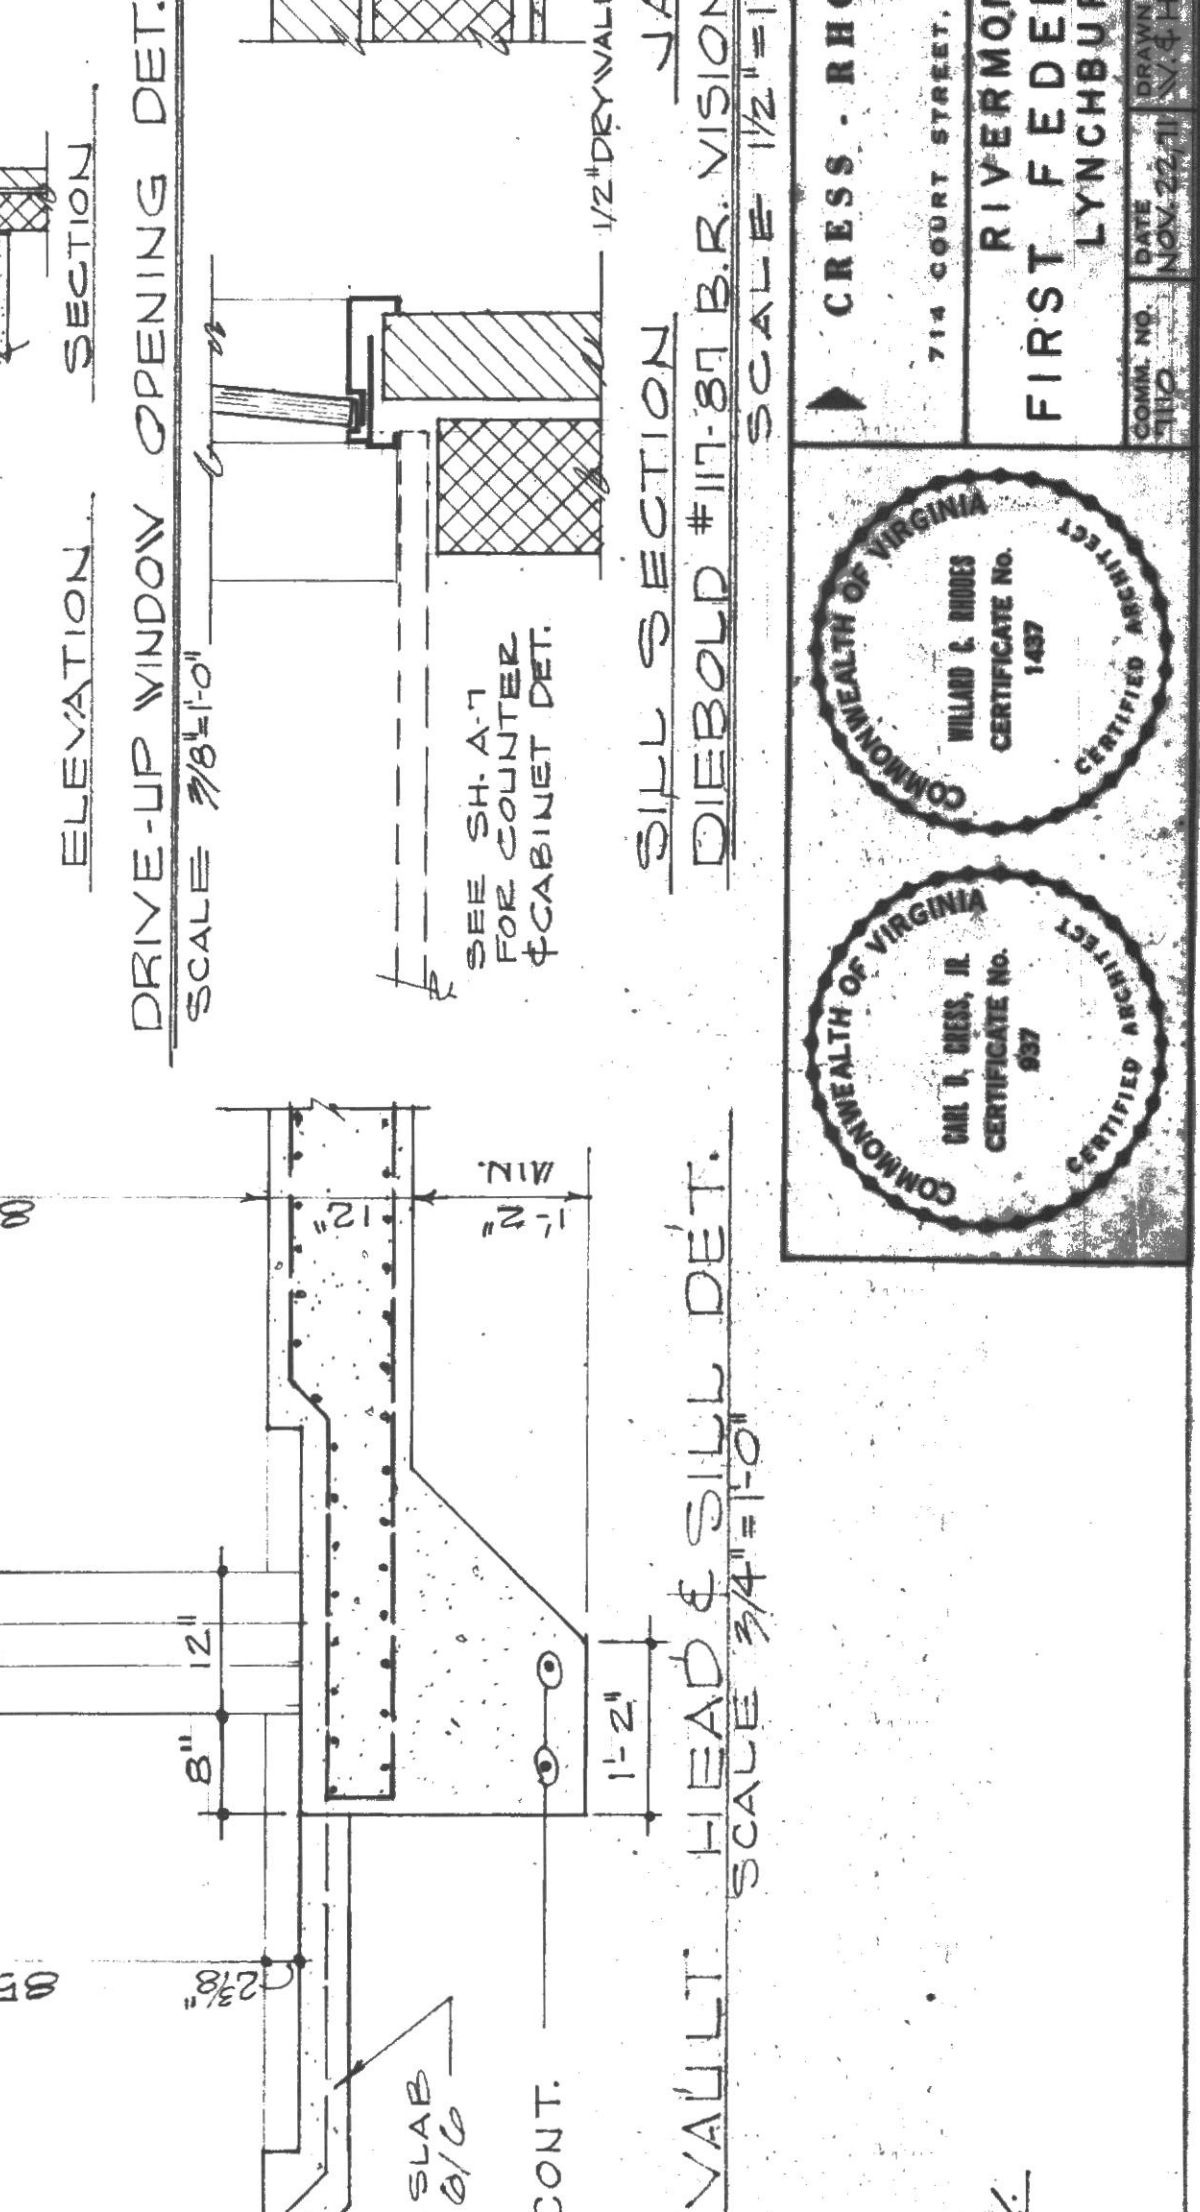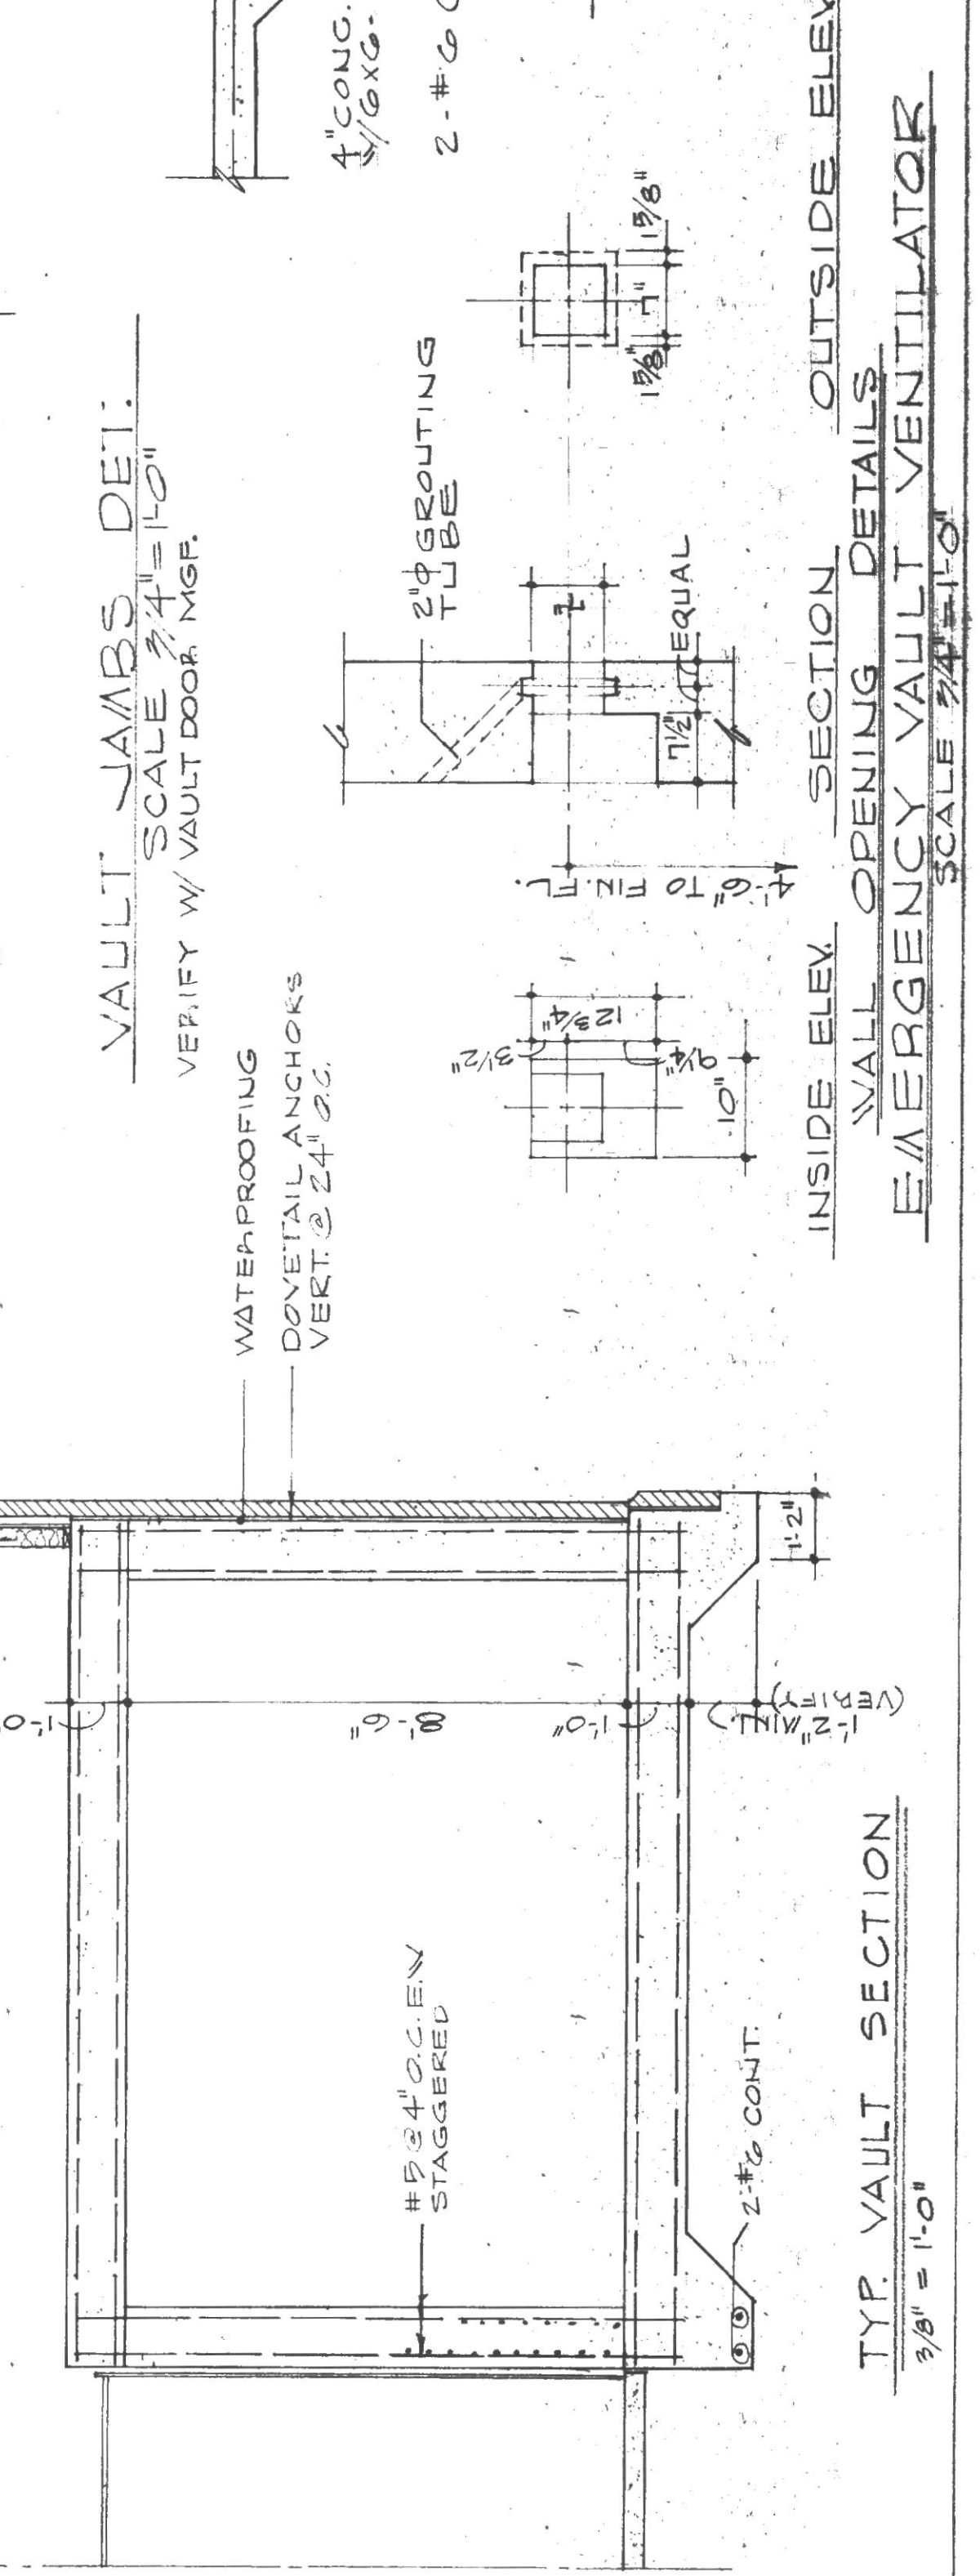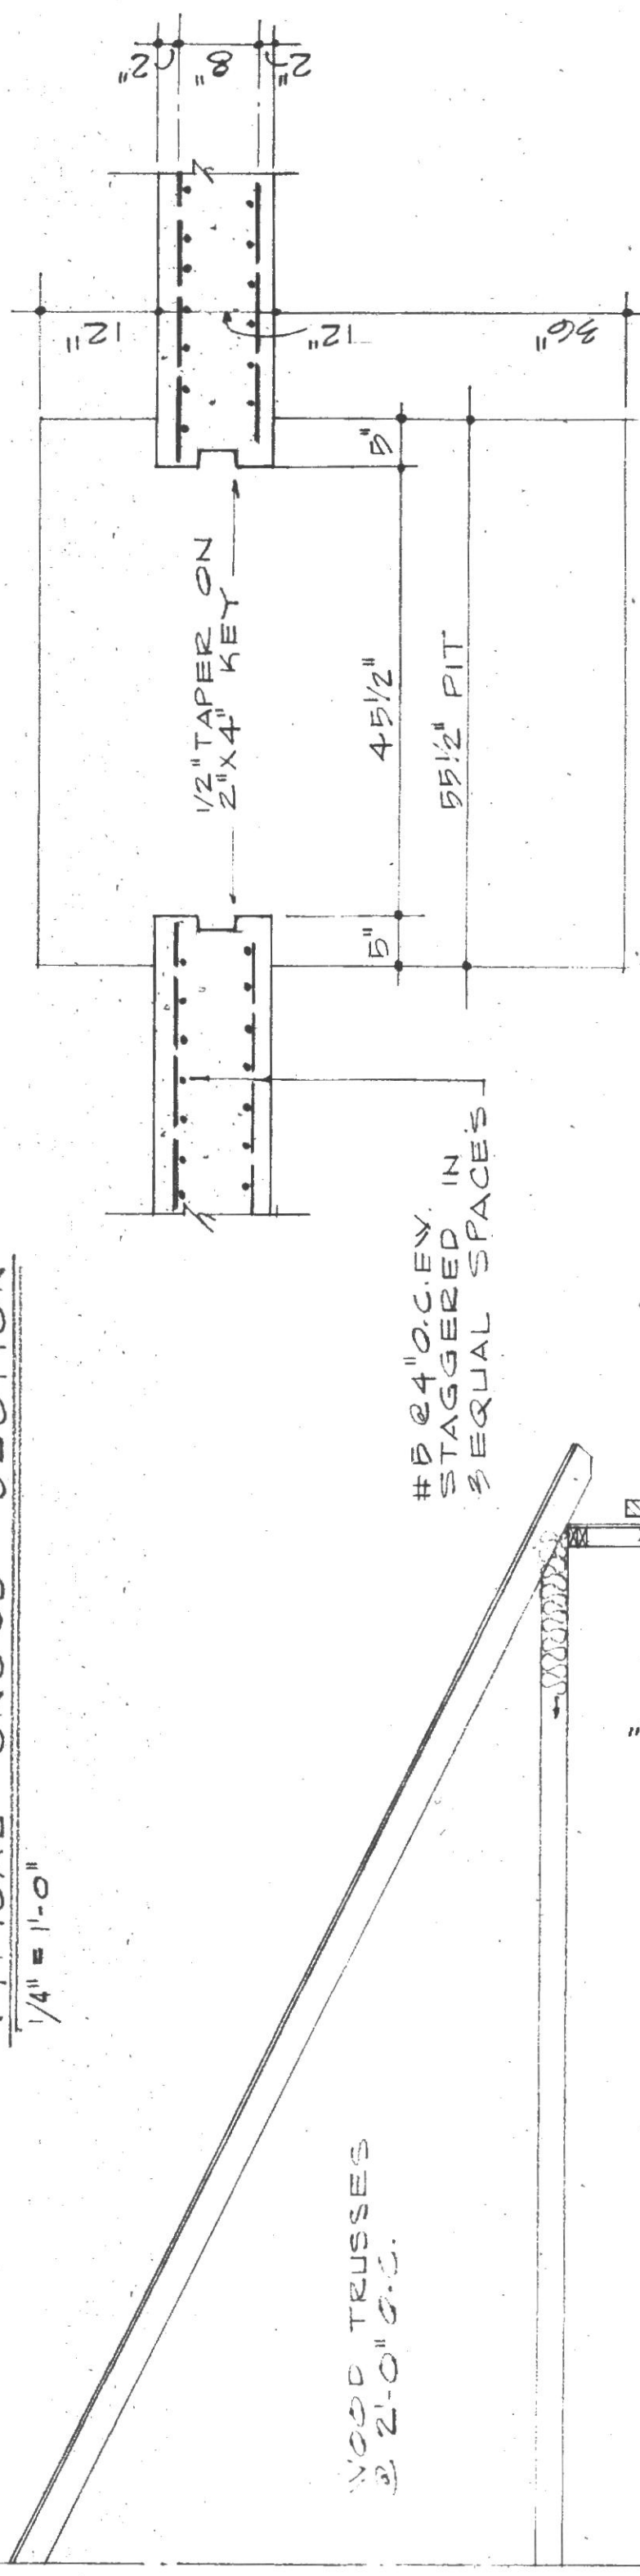


CRESS, RHODES & ASSOCIATES
 ARCHITECTS
 714 COURT STREET, LYNCHBURG, VIRGINIA
 RIVERMONT BRANCH
 FIRST FEDERAL SAVINGS BLOAN
 LYNCHBURG, VA.
 SHEET NO. A-5

- A U.S. PLYWOOD, QUARTER CHESTNUT
- B GREEN PAINT "CHRYSLER"
- C U.S. GYPSUM 1/2 SHEETROCK "CHALK" (447)
- D STAINED AREAS TO MATCH A.
- E OBEIDEN OFF. WHITE
- F CONSOLEUM "SEANDVIEW" VA-106
- G FORMICA 328 (44) CHERRY

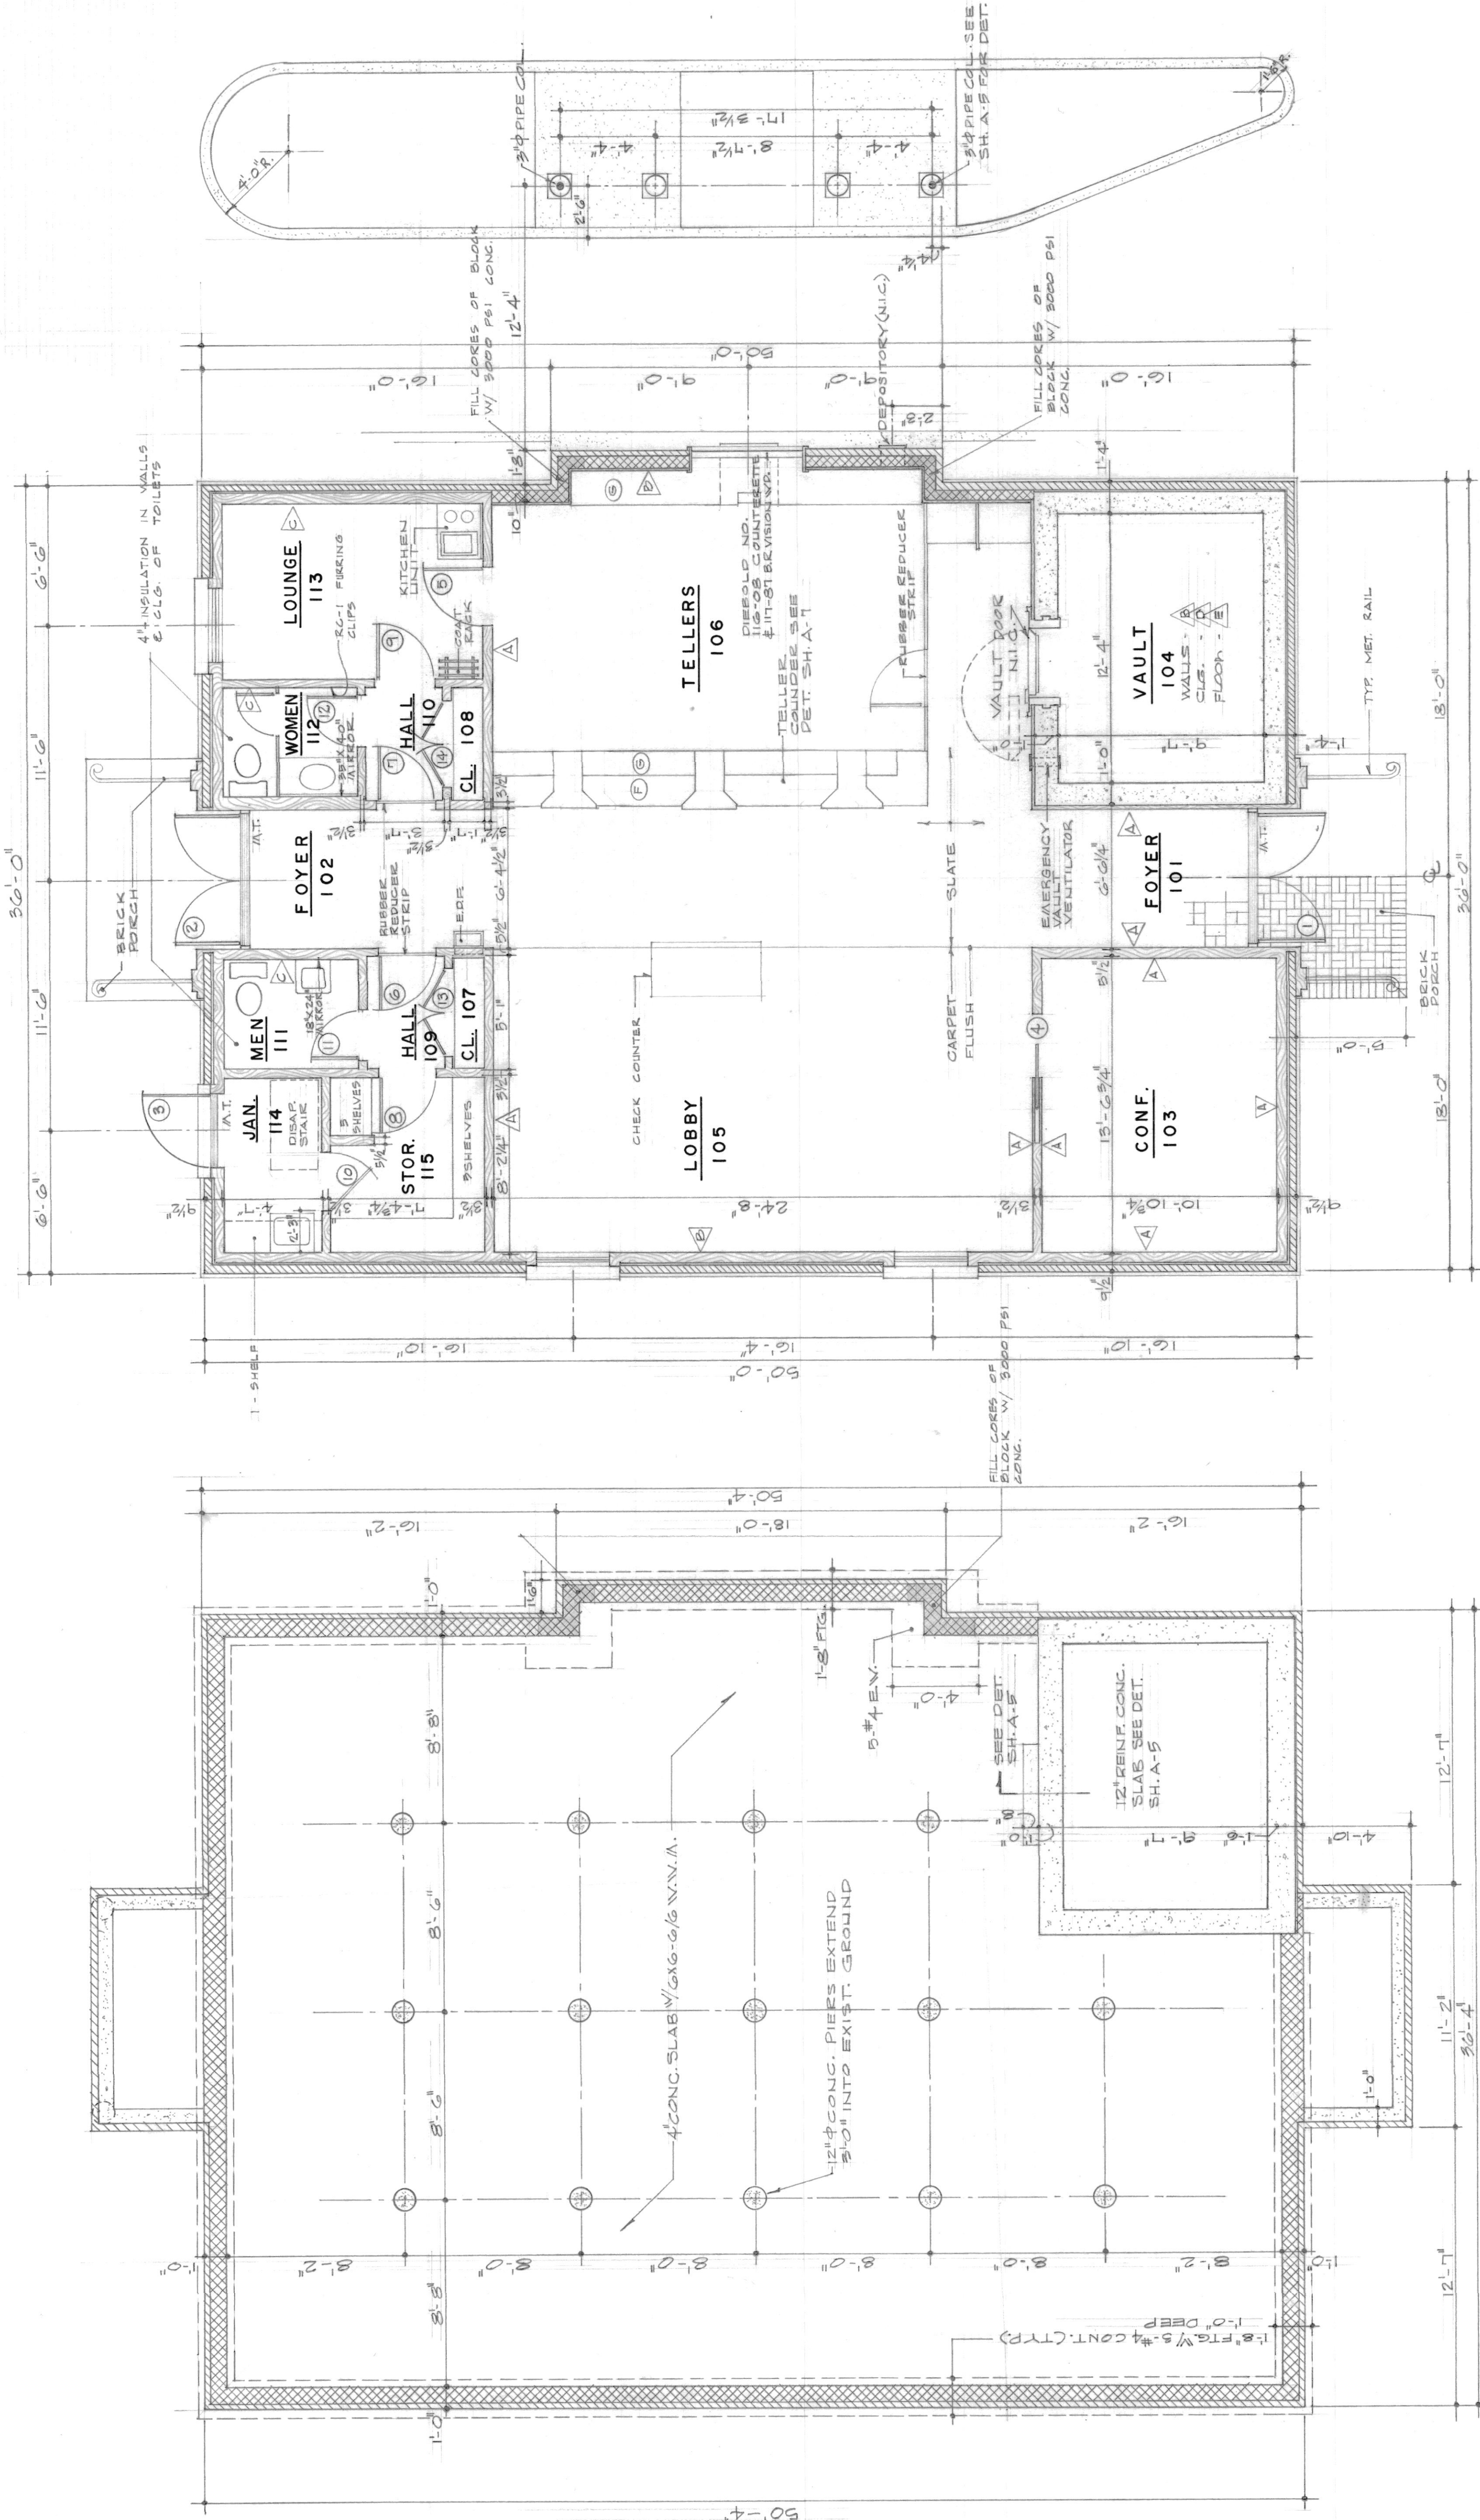

FOUNDATION PLAN
SCALE 1/4"=1'-0"

FLOOR PLAN
SCALE 1/4"=1'-0"

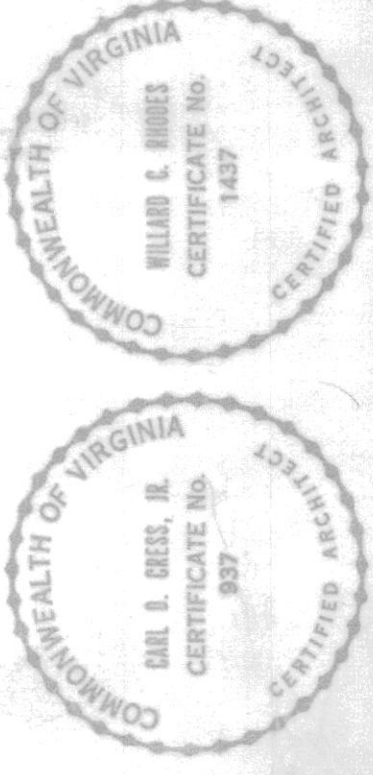


FINISH SCHEDULE

MARK	ROOM	FLOOR	BASE	WALLS	CEILING	Q.G.H.T.	REMARKS
101	FOYER	SLATE	WOOD	PANELING	DRYWALL	9'-1 1/2"	
102	FOYER						
103	CONF.	CARPET			ACoust. TILE	9'-0"	
104	VAULT	VINYL ASB		PAINTED CONC. DRYWALL	PAINTED CONC. DRYWALL	8'-6"	SEE CHECK COUNTER DETAIL SH. A-1
105	LOBBY	SLATE #			ACoust. TILE	9'-8"	RUBBER REDUCER STRIP 2 SLATE SEE TELLERS COUNTER DET.
106	TELLERS	VINYL ASB					
107	CL.			DRYWALL	DRYWALL	8'-0"	3 SHELVES
108	CL.						
109	HALL						RUBBER REDUCER STRIP 2 SLATE
110	HALL						RUBBER REDUCER STRIP 2 SLATE
111	MEN			VINYL SURFACED DRYWALL			LAM. PLASTIC COUNTER SELF-EDGE
112	WOMEN						
113	LOUNGE					8'-0"	
114	JAN.			DRYWALL		8'-0"	
115	STOR.						

DOOR SCHEDULE


MARK	TYPE	OPG. SIZE	THK.	MAT.	FRAME	REMARKS
1 & 2	FLUSH	PAIR 3'-0" X 7'-0"	1 3/4"	ALUM.	ALUM.	
3	6 PANEL	3'-4" X 7'-0"	1 3/4"	W.P.	W.P.	FIXED WOOD TRANSOM 6" EXTERIOR CASING
4		3'-0" X 6'-8"	1 3/8"			
5 & 6		2'-8" X 6'-8"				UNDERCUT 6" X 1 1/2"
7 & 8	FLUSH	2'-8" X 6'-8"		H.C. W.D.		UNDERCUT 8" X 1 1/2", 1 1/2"
11 & 12		2'-4" X 6'-8"				
13 & 14		PAIR 2'-0" X 6'-8"				

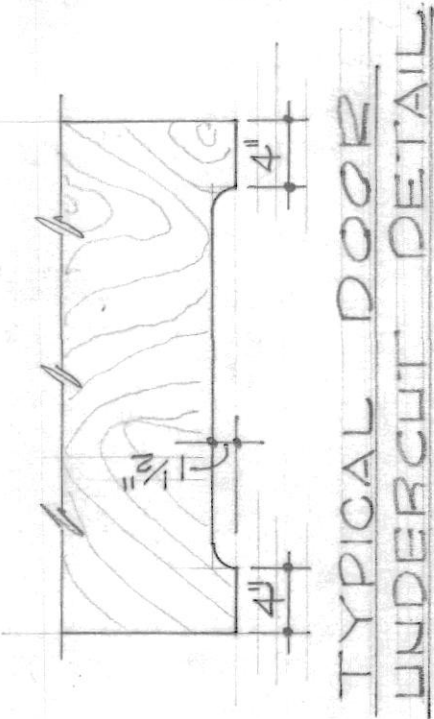

TYPICAL DOOR UNDERCUT DETAIL

1/4" PLY WOOD

1/4" PLY WOOD 1/2" DRY WALL 1/2" W.P. STO CASING

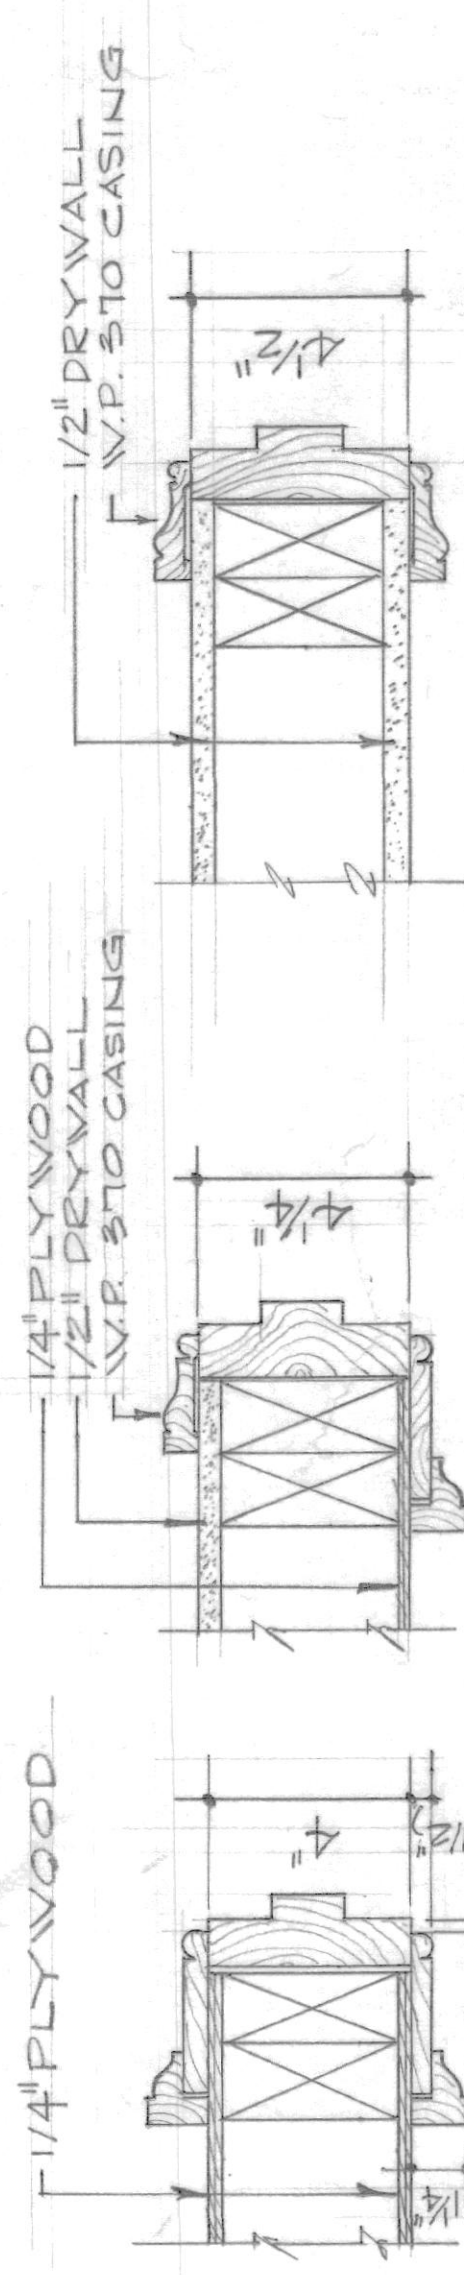


DOOR NO. 4 DET.

DOOR NO. 5, 6, 7 DET.

DOOR NO. 8 THRU NO. 14

TYPICAL DOOR DETAIL SCALE 3/8" = 1'-0"

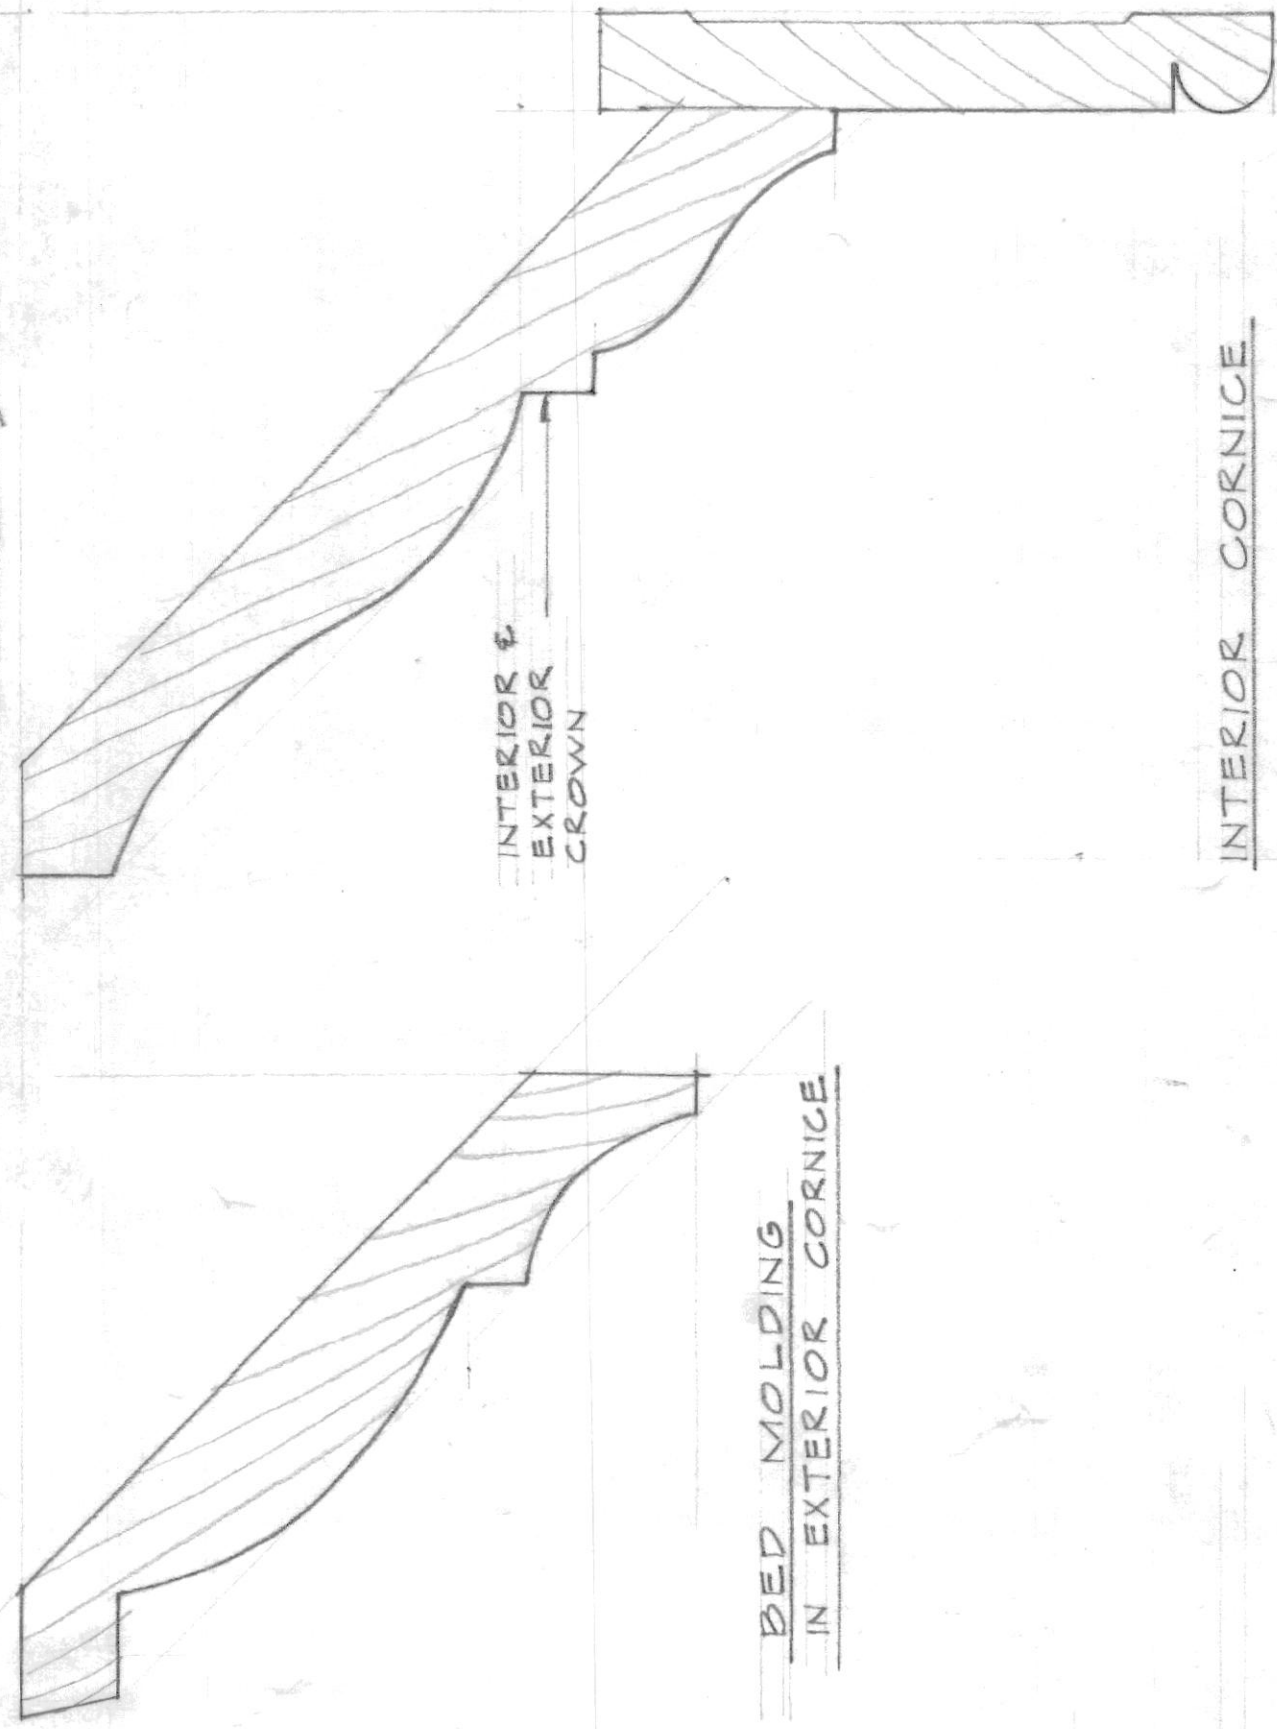

BASEBOARD

INTERIOR CORNICE


INTERIOR & EXTERIOR DOOR & WINDOW TRIM

SITE PLAN

SCALE 1" = 20'-0"
SITE PLAN INFORMATION TRACED BY ADRIAN EVERSTREET, S.C.S.
DATED OCT. 12, 1971

LEGEND

+ 74.73' EXIST. SPOT ELEV.
• 98.0' NEW SPOT ELEV.

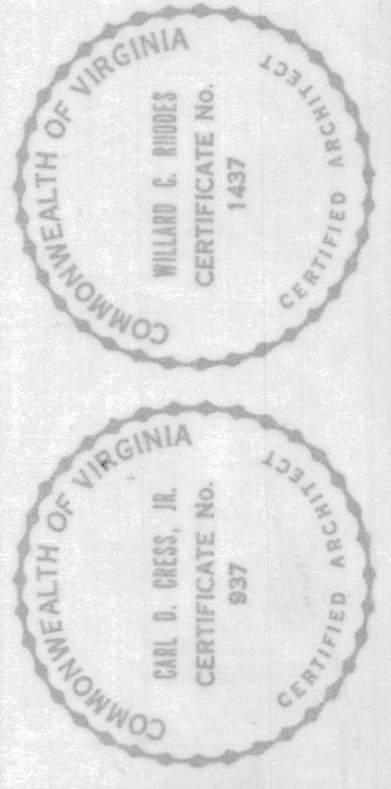

CRESS, RHODES & ASSOCIATES ARCHITECTS
714 COURT STREET, LYNCHBURG, VIRGINIA
RIVERMONT BRANCH
FIRST FEDERAL SAVINGS & LOAN A-1
LYNCHBURG, VA.
DATE NOV. 26, 71
DRAWN BY CHW:MMH
CHECKED BY V.C.R.
SHEET NO. 7 OF 7